


# THE PLEASANT VIEW MODEL

935 Pleasant View Rd, Chanhassen MN 55317

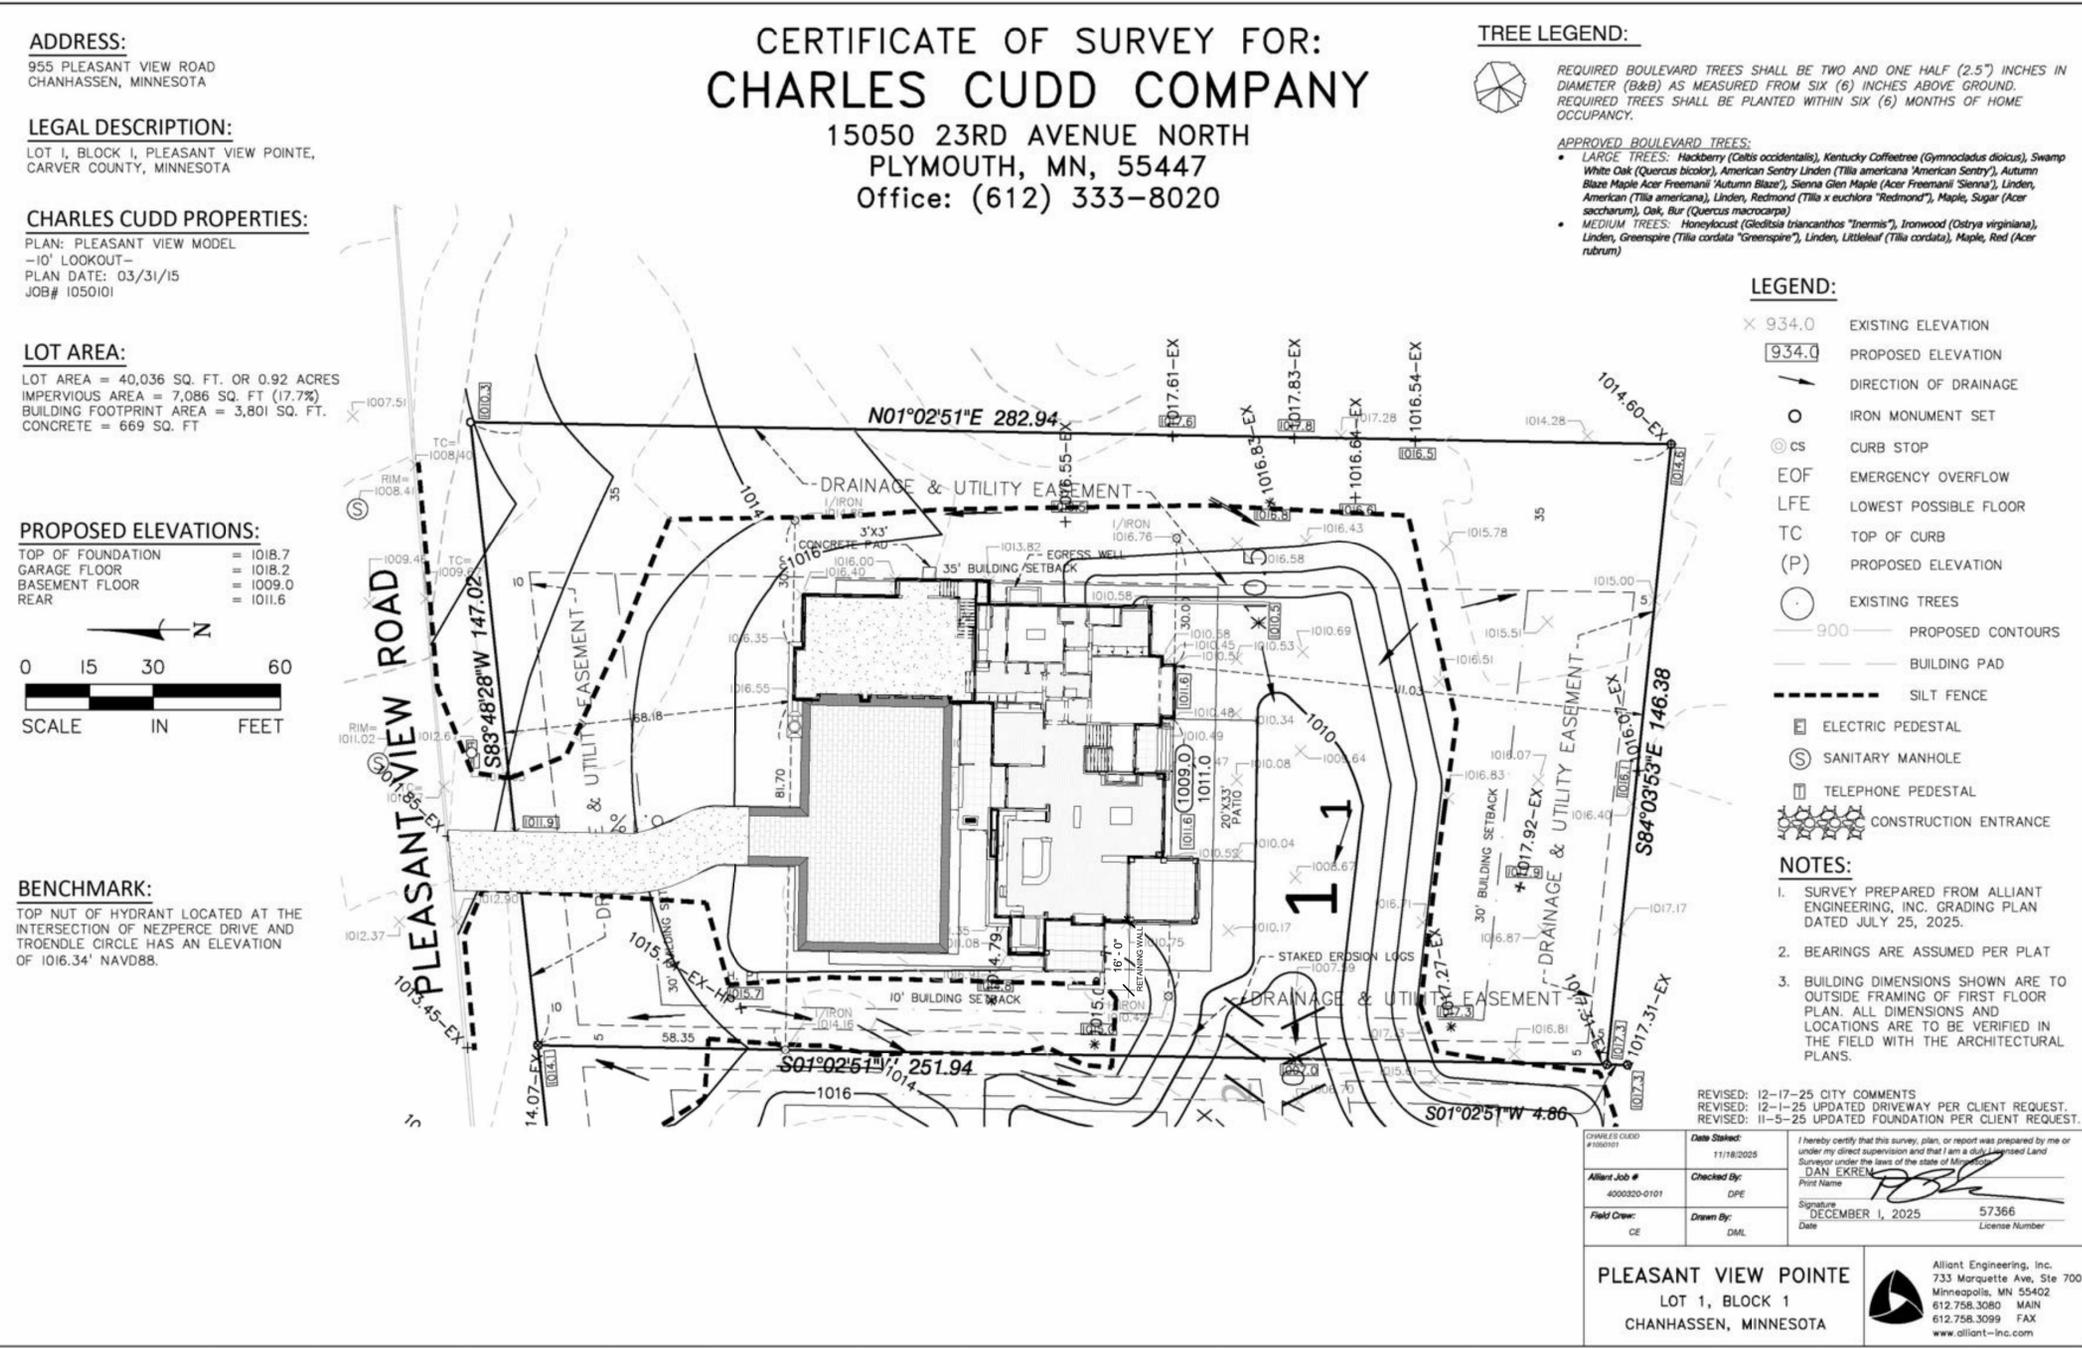

DRAWING INDEX	
Sheet Number	Sheet Name
T-1	Title
T-2	Perspective
T-3	Perspective
A-1	Foundation Plan
A-2	Lower Level
A-2.1	Lower Level Structural Plan
A-3	Main Level
A-3.1	Main Level Structural Plan
A-4	Upper Level
A-5	Front Elevation
A-6	Right Elevation
A-7	Left Elevation
A-8	Rear Elevation
A-9	Roof Plan
A-10	Building Sections
A-11	Building Sections
A-12	Building Sections
A-13	Building Sections
A-14	Building Sections
I-1	Interior Elevations
I-2	Interior Elevations
I-3	Interior Elevations
I-4	Interior Perspectives
I-5	Interior Perspectives
I-6	Interior Perspectives
S-1	Structural Details
S-2	Structural Details
E-1	Electrical Plan Lower Level
E-2	Electrical Plan Main Level

**CHARLES CUDD CO.**  
ARCHITECTURAL DESIGN • BUILD

15050 23rd Ave. N. • Plymouth, MN 55447 • 612-333-8020 Phone  
charlescudd.com

RESIDENCE FOR: Pleasant View Model  
ADDRESS: 935 Pleasant View Rd, Chanhassen MN 55317  
LOT No.: 01 BLOCK No.: 01  
PROJECT: Custom Home  
JOB No.: 1050101

Revision Schedule	Description	Date
#		

DATE DRAWN: 05.15.2023	CUSTOMER: TBD	PLAN REVIEW: TBD	RELEASE: JCB	DRAWN BY: JCB
------------------------	---------------	------------------	--------------	---------------

**SHEET INDEX**

T-1	Title
T-2/5	Exterior Perspectives
A-1	Foundation Plan
A-2	Lower Level Finish Plan
A-3	Main Level Floor Plan
A-4	Front Elevation
A-5	Right Elevation
A-6	Left Elevation
A-7	Rear Elevation & Roof
A-8/10	Building Sections
A-11	Wall Sections
I-1/3	Interior Elevations
S-1/2	Framing Plan & Details
E-1/2	Electrical Plans

T-1

Title

# THE PLEASANT VIEW MODEL

935 Pleasant View Rd, Chanhassen MN 55317



**CHARLES CUDDO CO.**  
ARCHITECTURAL DESIGN • BUILD  
15000 23rd Ave. N. • Plymouth, MN 55447 • 612-333-8020 Phone  
charlescuddo.com

© Charles Cuddo Co.  
THESE PLANS AND THE WORK CONSTRUCTED PURSUANT TO THEM ARE THE SOLE PROPERTY OF CHARLES CUDDO CO. ANY REPRODUCTION OR USE OF THESE PLANS WITHOUT THE WRITTEN PERMISSION OF CHARLES CUDDO CO. IS STRICTLY PROHIBITED.  
COPYRIGHT © 2023

I HEREBY CERTIFY THAT THIS PLAN WAS PREPARED BY ME OR UNDER MY CLOSE PERSONAL SUPERVISION AND THAT I AM A LICENSED ARCHITECT REGISTERED UNDER THE LAWS OF THE STATE OF MINNESOTA.  
DATE: \_\_\_\_\_  
SIGN: \_\_\_\_\_  
REG. NO: \_\_\_\_\_

RESIDENCE FOR: Pleasant View Model  
ADDRESS: 935 Pleasant View Rd, Chanhassen MN 55317  
LOT No.: 01 BLOCK No.: 01  
PROJECT: Custom Home  
JOB No.: 1050101

Revision Schedule	
#	Date

DATE DRAWN: 03/31/15  
CUSTOMER: TBD  
PLAN REVIEW: Approver  
RELEASE: Approver  
DRAWN BY: JCB

**SHEET INDEX**

T-1	Title
T-2/5	Exterior Perspectives
A-1	Foundation Plan
A-2	Lower Level Finish Plan
A-3	Main Level Floor Plan
A-4	Front Elevation
A-5	Right Elevation
A-6	Left Elevation
A-7	Rear Elevation & Roof
A-8/10	Building Sections
A-11	Wall Sections
I-1/3	Interior Elevations
S-1/2	Framing Plan & Details
E-1/2	Electrical Plans

**T-2**  
Perspective

# THE PLEASANT VIEW MODEL

935 Pleasant View Rd, Chanhassen MN 55317



**CHARLES CUDDO CO.**  
ARCHITECTURAL DESIGN • BUILD  
15000 23rd Ave. N. • Plymouth, MN 55447 • 612-333-8020 Phone  
charlescuddo.com

© Charles Cuddo Co.  
THESE PLANS AND THE WORK CONSTRUCTED PURSUANT TO THEM ARE THE PROPERTY OF CHARLES CUDDO CO. ANY REPRODUCTION OR DISTRIBUTION OF THESE PLANS WITHOUT THE WRITTEN PERMISSION OF CHARLES CUDDO CO. IS STRICTLY PROHIBITED.  
COPYRIGHT © 2023

I HEREBY CERTIFY THAT THIS PLAN WAS PREPARED BY ME OR UNDER MY CLOSE PERSONAL SUPERVISION AND THAT I AM A LICENSED ARCHITECT UNDER THE LAWS OF THE STATE OF MINNESOTA.  
SIGN: \_\_\_\_\_ DATE: \_\_\_\_\_  
REG. NO.: \_\_\_\_\_

RESIDENCE FOR: Pleasant View Model  
ADDRESS: 935 Pleasant View Rd, Chanhassen MN 55317  
LOT No.: 01 BLOCK No.: 01  
PROJECT: Custom Home  
JOB No.: 1050101

Revision Schedule		
#	Description	Date

DATE DRAWN: 05/05/23  
CUSTOMER: TBD  
PLAN REVIEW: \_\_\_\_\_  
RELEASE: Approver  
DRAWN BY: Author

**SHEET INDEX**


T-1	Title
T-2/5	Exterior Perspectives
A-1	Foundation Plan
A-2	Lower Level Finish Plan
A-3	Main Level Floor Plan
A-4	Front Elevation
A-5	Right Elevation
A-6	Left Elevation
A-7	Rear Elevation & Roof
A-8/10	Building Sections
A-11	Wall Sections
I-1/3	Interior Elevations
S-1/2	Framing Plan & Details
E-1/2	Electrical Plans

**T-3**  
Perspective

### FOUNDATION PLAN NOTES:

- REFER TO SILL PLATE AND FLOOR DETAILS LOCATED ON PAGE S3 AND STRUCTURAL DRAWINGS FOR ADDITIONAL DETAILS
- TOP OF POURED WALL TO BE 100.00
  - TOP OF BASEMENT SLAB TO BE 99.33
  - PROVIDE 6"W X 4"H TREATED CURB ON 18"W X 8"H CONC. STRIP FOOTINGS AT BEARING WALLS AS SHOWN
  - PROVIDE FOUR #4 RE-BAR EACH WAY AT ALL PAD FOOTINGS SHOWN - MIN. 3" CLEARANCE TO SOIL
  - ALL PAD FOOTINGS SHOWN TO BE 12" THICK - SIZE AS DIMENSIONED
  - SEE BUILDING SECTIONS FOR ADDITIONAL NOTE & DETAILS
  - CONC. PATIO AREA TO BE DETERMINED BY LANDSCAPE ARCHITECT
  - XX SQ. FT. STD. BROOM FINISH CONCRETE SIDEWALK
  - SEE PAGE AXX FOR LOWER LEVEL FINISH PLAN
  - DIMENSIONS ARE FROM FACE OF CONCRETE WALL
  - BOTTOM OF HOUSE FOOTING TO BE 89.33
  - BOTTOM OF GARAGE FOOTING TO BE 95.33

### BEARING WALL DETAIL

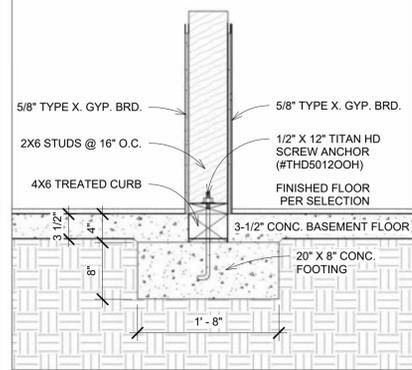

2 Typical Bearing Wall Detail

1" = 1'-0"

1 Foundation Plan


1/4" = 1'-0"

### FOUNDATION WALLS DISCLOSURE:

FOUNDATION WALL HEIGHTS ARE SUBJECT TO CHANGE DUE TO GRADE AND SITE CONDITIONS.

ALL FOUNDATION WALL HEIGHTS MUST BE VERIFIED ON SITE BY THE CONTRACTOR AND SITE SURVEYOR PRIOR TO CONSTRUCTION.

FOUNDATION CONTRACTOR WILL STEP FOUNDATION WALLS AS NECESSARY TO MAINTAIN PROPER FROST PROTECTION (42" BELOW GRADE) IN ACCORDANCE TO CURRENT MINNESOTA CODE, REGULATIONS, AND ZONING.

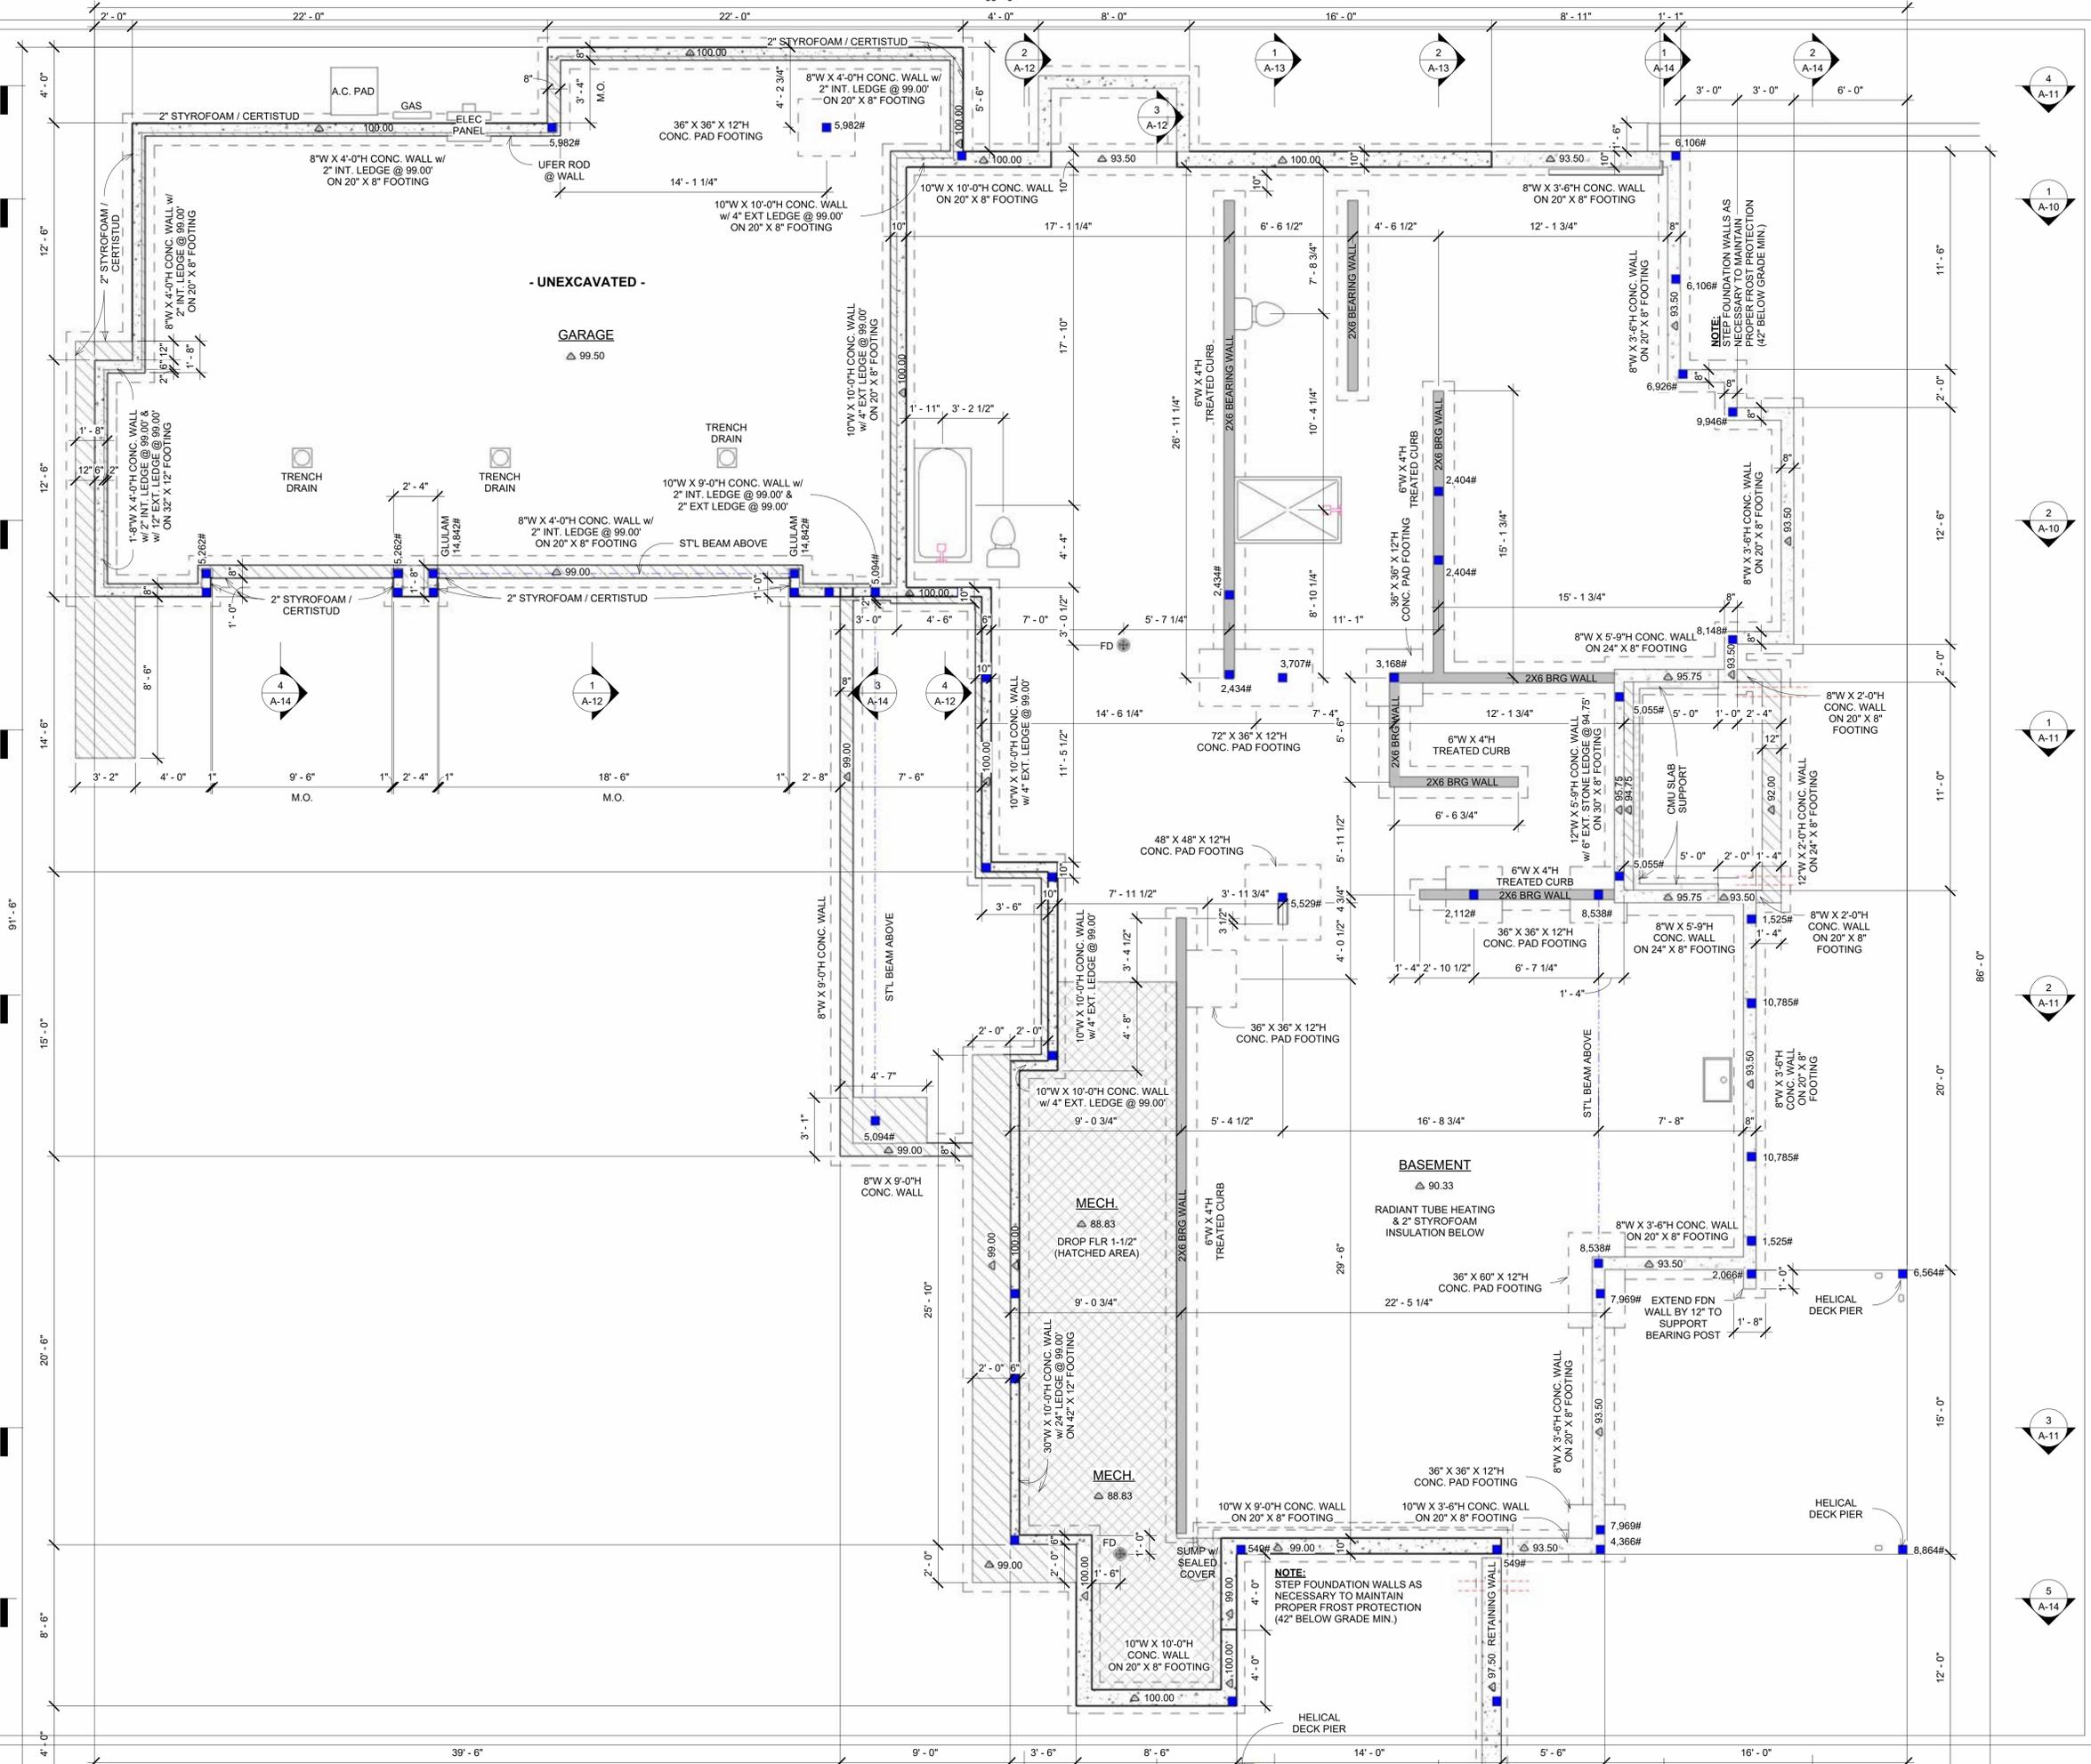

**CHARLES CUDDOO**  
ARCHITECTURAL DESIGN • BUILD

15050 23rd Ave. N. • Plymouth, MN 55447 • 612-333-8020 Phone  
charlescuddoo.com

© Charles Cuddoo Co.

THESE PLANS AND THE WORK CONSTRUCTED PURSUANT TO THEM ARE THE SOLE PROPERTY OF CHARLES CUDDOO ARCHITECTURAL DESIGN • BUILD. NO PART OF THESE PLANS OR THE WORK SHALL BE REPRODUCED OR TRANSMITTED IN ANY FORM OR BY ANY MEANS, ELECTRONIC OR MECHANICAL, WITHOUT THE WRITTEN PERMISSION OF CHARLES CUDDOO ARCHITECTURAL DESIGN • BUILD.

DATE: \_\_\_\_\_  
SCALE: \_\_\_\_\_  
SHEET NO: \_\_\_\_\_  
PROJECT NO: \_\_\_\_\_

RESIDENCE FOR: Pleasant View Model  
935 Pleasant View Rd, Chamhassen  
ADDRESS: MN 55317  
LOT No.: 01 BLOCK No.: 01  
PROJECT: Custom Home  
JOB No.: 1050101

Revision	Schedule	Description	Date

DATE DRAWN: 02/07/20  
CUSTOMER: TBD  
PLAN REVIEW: TBD  
RELEASE: Approver  
DRAWN BY: Author

**SHEET INDEX**


- T-1 Title
- T-2/5 Exterior Perspectives
- A-1 Foundation Plan
- A-2 Lower Level Finish Plan
- A-3 Main Level Floor Plan
- A-4 Front Elevation
- A-5 Right Elevation
- A-6 Left Elevation
- A-7 Rear Elevation & Roof
- A-8/10 Building Sections
- A-11 Wall Sections
- I-1/3 Interior Elevations
- S-1/2 Framing Plan & Details
- E-1/2 Electrical Plans

**A-1**  
Foundation Plan

# LOWER LEVEL NOTES:

- DIMENSIONS ARE TO CENTER OF INTERIOR WALLS / FACE OF EXTERIOR STUD OR CONCRETE FOUNDATION WALL.
- TYPICAL WINDOW HEADER TO BE 2-2X12'S UNLESS NOTED OTHERWISE
- TYPICAL ROUGH OPNG HEADER HEIGHT TO BE 7'-9 3/4" OFF ROUGH FLR
- ALL LOOKOUT WINDOW ROUGH OPENINGS TO HAVE
- 1-2X6 TREATED SILL PLATES ON FOUNDATION WALL
- SEE PAGE E-1 FOR LOWER LEVEL ELECTRICAL PLAN
- PROVIDE SPACE TO ACCOMMODATE 5 1/4" BASE AND 3 1/4" CASING
- WINDOW GRIDS TO BE BETWEEN GLASS

REVIEW BRACED WALL PLAN LOCATED AT THE END OF THE SET FOR STRUCTURAL PANEL & MOMENT FRAMING LOCATIONS/DETAILS

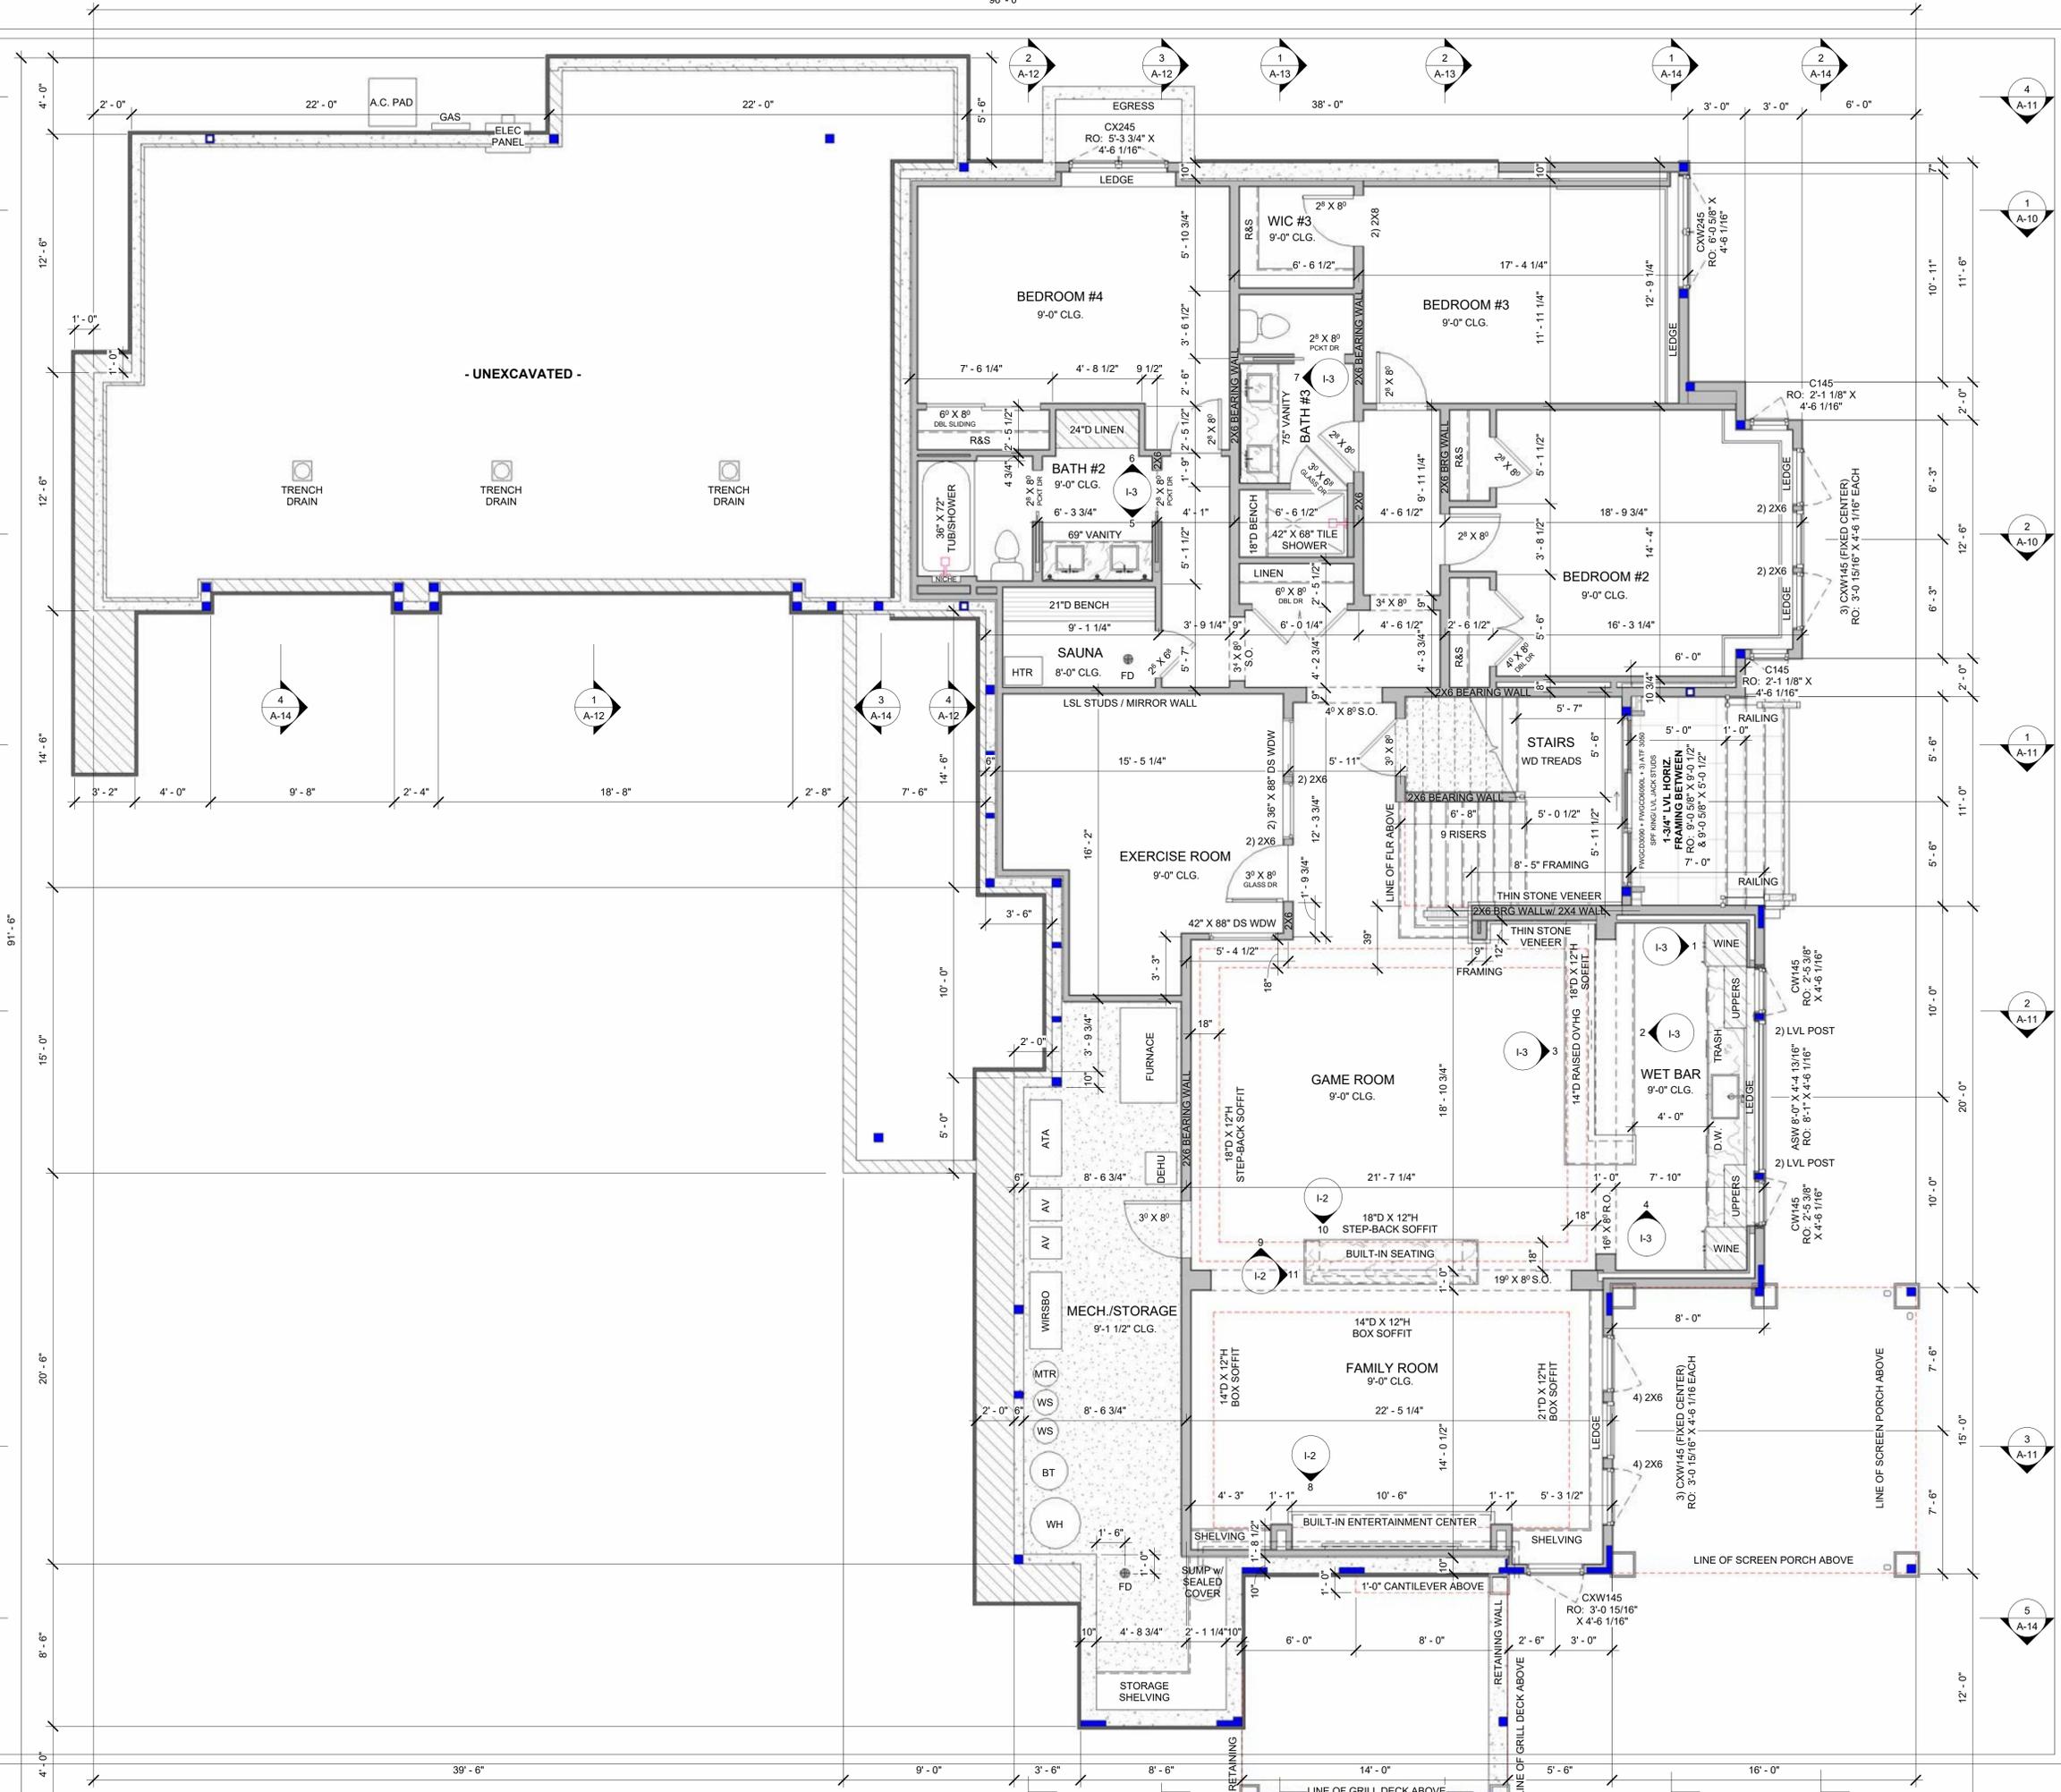

1 Lower Level

1/4" = 1'-0"

**CHARLES CUDDOO**  
ARCHITECTURAL DESIGN • BUILD

15000 23rd Ave. N. • Plymouth, MN 55447 • 612-333-8020 Phone  
charlescuddoo.com

© Charles Cuddoo Co.  
THESE PLANS AND THE WORK CONSTRUCTED HEREUNDER ARE THE SOLE PROPERTY OF CHARLES CUDDOO ARCHITECTURAL DESIGN • BUILD. NO PART OF THESE PLANS OR THE WORK CONSTRUCTED HEREUNDER MAY BE REPRODUCED OR TRANSMITTED IN ANY FORM OR BY ANY MEANS, ELECTRONIC OR MECHANICAL, WITHOUT THE WRITTEN PERMISSION OF CHARLES CUDDOO ARCHITECTURAL DESIGN • BUILD. COPYRIGHT © 2023

I HEREBY CERTIFY THAT THIS PLAN WAS PREPARED BY ME OR UNDER MY CLOSE PERSONAL SUPERVISION AND TO THE BEST OF MY KNOWLEDGE AND BELIEF IT COMPLIES WITH ALL CITY, STATE AND FEDERAL REQUIREMENTS UNDER THE LAWS OF THE STATE OF MINNESOTA.

DATE: \_\_\_\_\_  
SIGN: \_\_\_\_\_  
REG. NO: \_\_\_\_\_

RESIDENCE FOR: **Pleasant View Model**  
935 Pleasant View Rd, Chamnassen  
ADDRESS: MN 55317  
LOT No.: 01 BLOCK No.: 01  
PROJECT: Custom Home  
JOB No.: 1050101

Revision Schedule	
#	Description / Date

DATE DRAWN: 10/15/14  
CUSTOMER: TBD  
PLAN REVIEW: TBD  
RELEASE: Approver  
DRAWN BY: Author

**SHEET INDEX**

- T-1 Title
- T-2/5 Exterior Perspectives
- A-1 Foundation Plan
- A-2 Lower Level Finish Plan
- A-3 Main Level Floor Plan
- A-4 Front Elevation
- A-5 Right Elevation
- A-6 Left Elevation
- A-7 Rear Elevation & Roof
- A-8/10 Building Sections
- A-11 Wall Sections
- I-1/3 Interior Elevations
- S-1/2 Framing Plan & Details
- E-1/2 Electrical Plans


**A-2**  
Lower Level

# LOWER LEVEL NOTES:

DIMENSIONS ARE TO CENTER OF INTERIOR WALLS / FACE OF EXTERIOR STUD OR CONCRETE FOUNDATION WALL.

- TYPICAL WINDOW HEADER TO BE 2-2X12'S UNLESS NOTED OTHERWISE
- TYPICAL ROUGH OPNG HEADER HEIGHT TO BE 7'-9 3/4" OFF ROUGH FLR
- ALL LOOKOUT WINDOW ROUGH OPENINGS TO HAVE
- 1-2X6 TREATED SILL PLATES ON FOUNDATION WALL
- SEE PAGE E-1 FOR LOWER LEVEL ELECTRICAL PLAN
- PROVIDE SPACE TO ACCOMMODATE 5 1/4" BASE AND 3 1/4" CASING
- WINDOW GRIDS TO BE BETWEEN GLASS

REVIEW BRACED WALL PLAN LOCATED AT THE END OF THE SET FOR STRUCTURAL PANEL & MOMENT FRAMING LOCATIONS/DETAILS

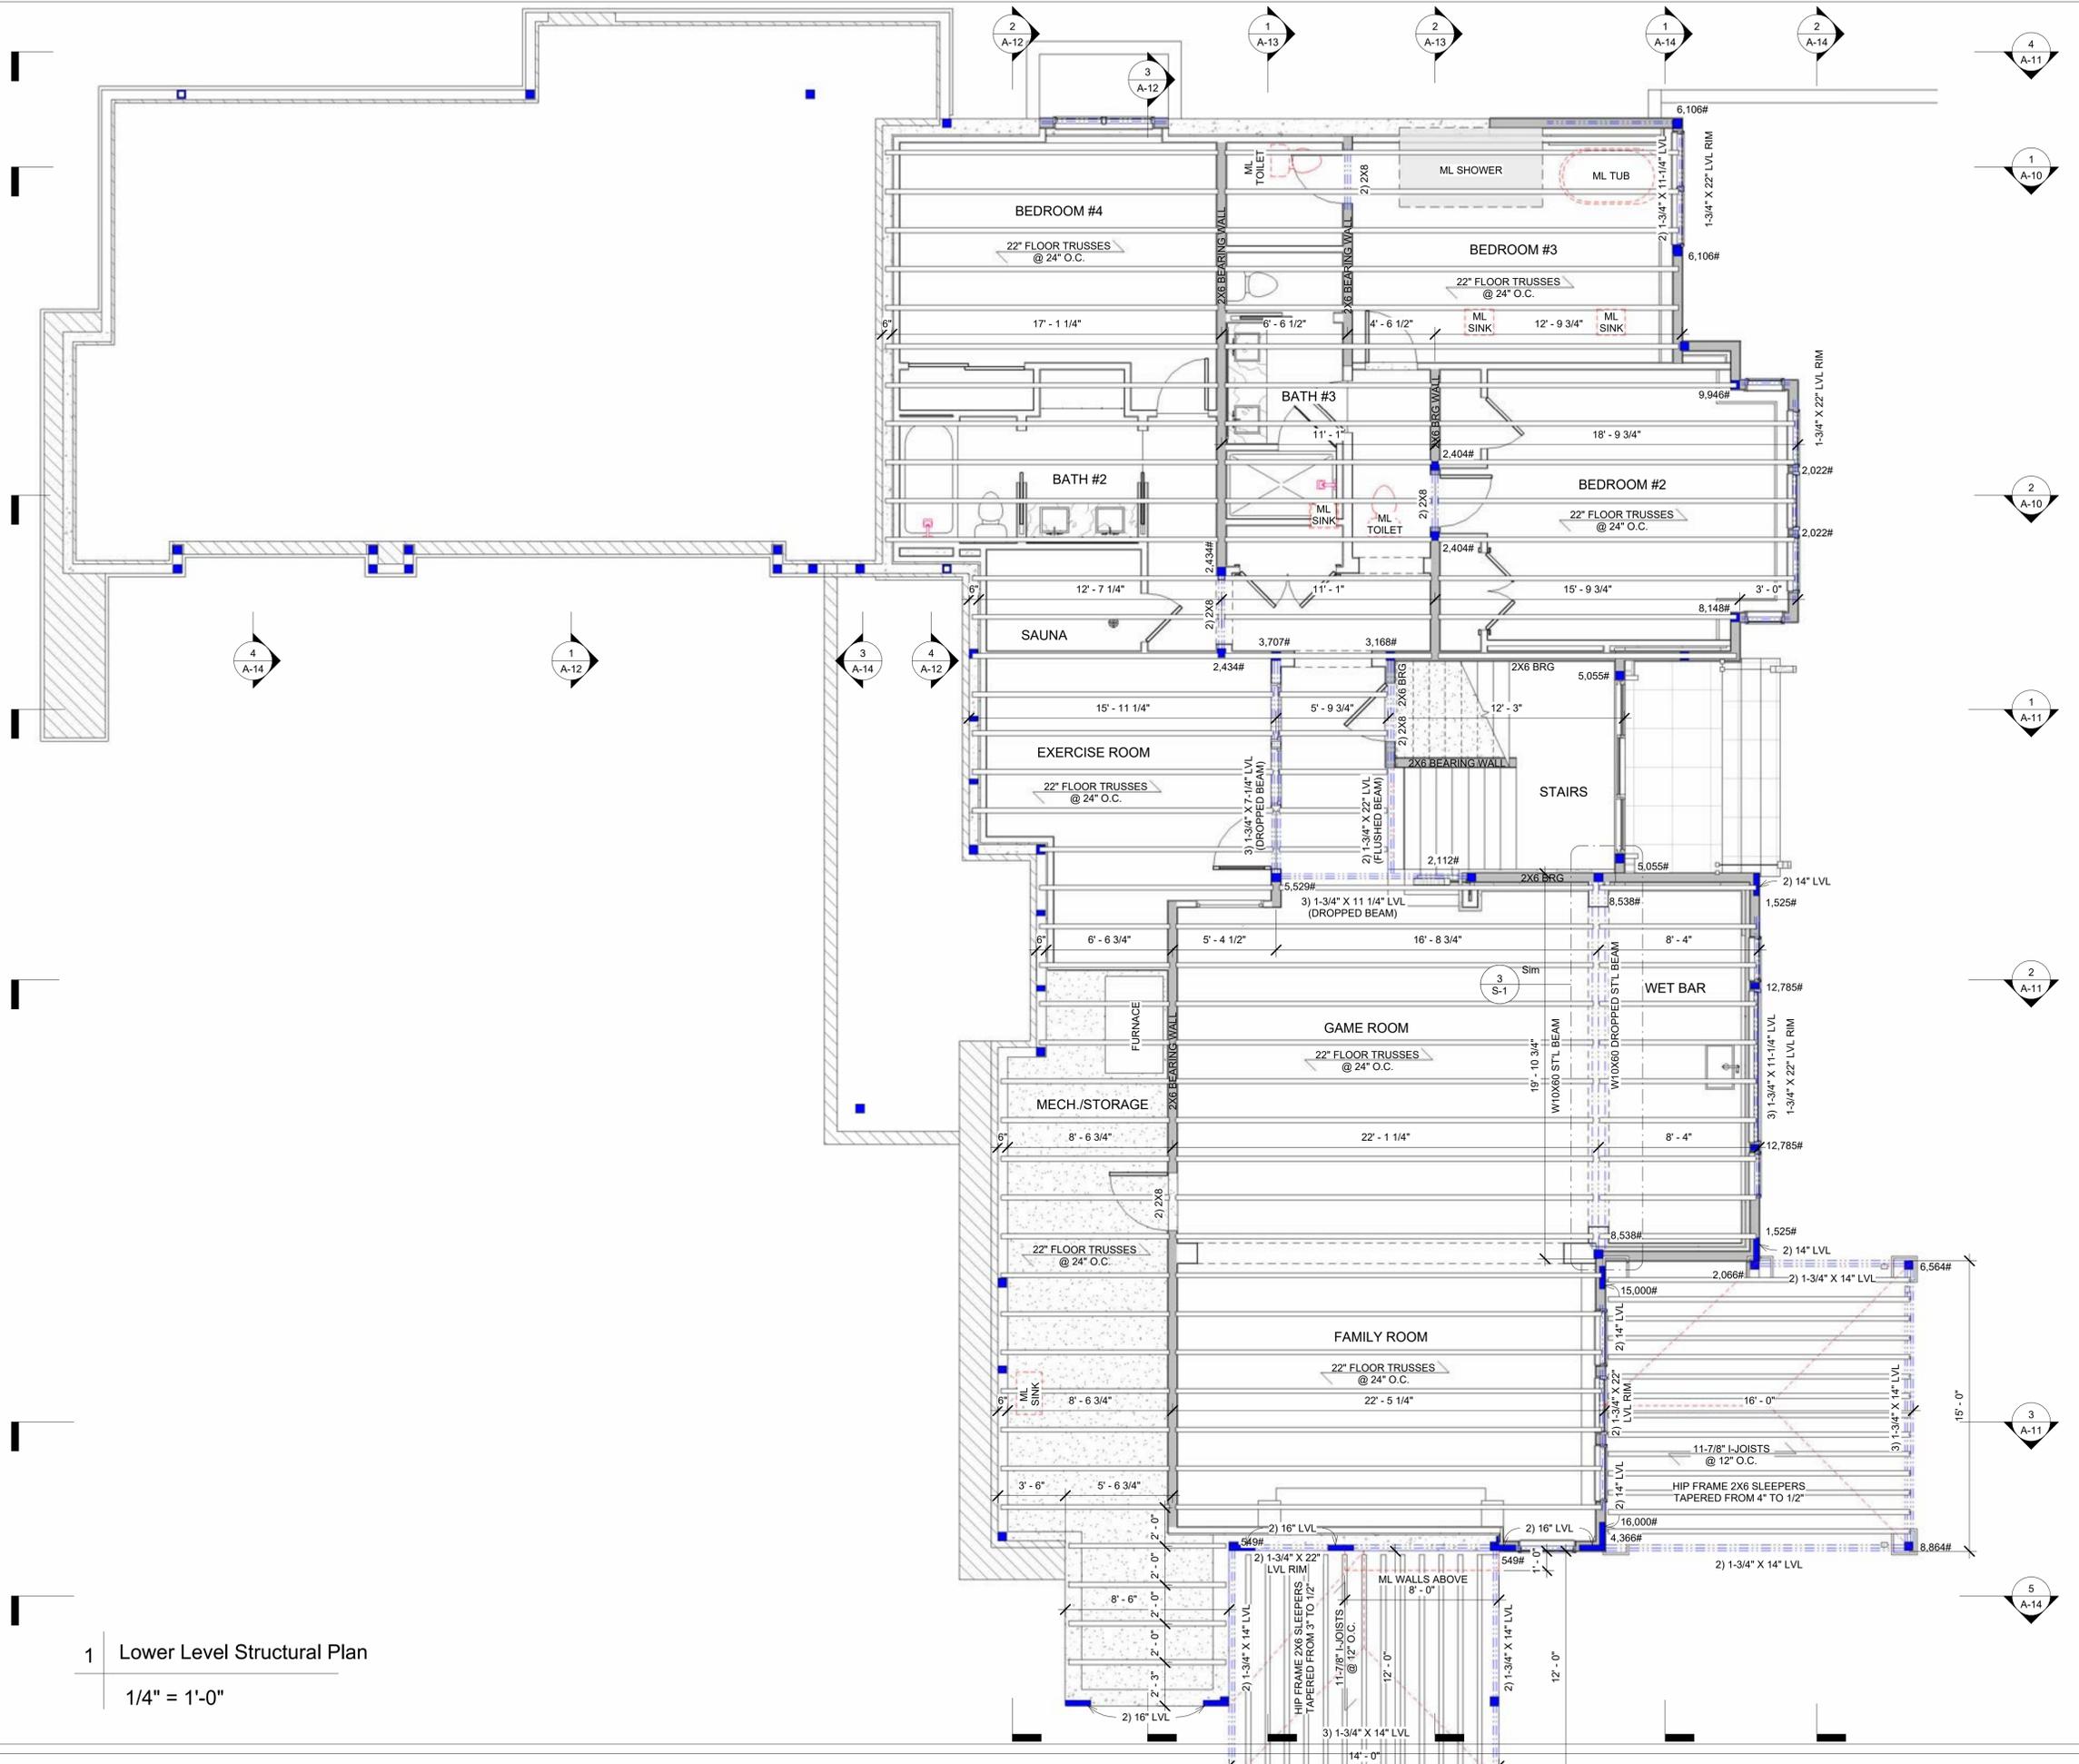

1 Lower Level Structural Plan  
1/4" = 1'-0"

**CHARLES CUDDOO**  
ARCHITECTURAL DESIGN • BUILD

15030 23rd Ave. N. • Plymouth, MN 55447 • 612-333-8020 Phone  
charlescuddoo.com

© Charles Cudd Co.

THESE PLANS AND THE WORK CONSTRUCTED PURSUANT TO THEM ARE THE SOLE PROPERTY OF CHARLES CUDDOO ARCHITECTURAL DESIGN • BUILD. NO PART OF THESE PLANS OR THE WORK SHALL BE REPRODUCED OR TRANSMITTED IN ANY FORM OR BY ANY MEANS, ELECTRONIC OR MECHANICAL, WITHOUT THE WRITTEN PERMISSION OF CHARLES CUDDOO ARCHITECTURAL DESIGN • BUILD.

I HEREBY CERTIFY THAT THESE PLANS WERE PREPARED BY ME OR UNDER MY CLOSE PERSONAL SUPERVISION AND TO THE BEST OF MY KNOWLEDGE AND BELIEF THEY COMPLY WITH ALL CITY, STATE AND FEDERAL REQUIREMENTS UNDER THE LAWS OF THE STATE OF MINNESOTA.

DATE: \_\_\_\_\_  
SIGN: \_\_\_\_\_  
REG. NO: \_\_\_\_\_

RESIDENCE FOR: **Pleasant View Model**  
935 Pleasant View Rd, Chamnassen  
ADDRESS: MN 55317  
LOT No.: \_\_\_\_\_  
PROJECT: Custom Home  
JOB No.: 1050101

Checklist LOCK No.: \_\_\_\_\_  
Designer

Revision #	Schedule	Description	Date

DATE DRAWN: 02/26/26  
CUSTOMER: TBD  
PLAN REVIEW: TBD  
RELEASE: Approver  
DRAWN BY: Author

**SHEET INDEX**

T-1	Title
T-2/5	Exterior Perspectives
A-1	Foundation Plan
A-2	Lower Level Finish Plan
A-3	Main Level Floor Plan
A-4	Front Elevation
A-5	Right Elevation
A-6	Left Elevation
A-7	Rear Elevation & Roof
A-8/10	Building Sections
A-11	Wall Sections
I-1/3	Interior Elevations
S-1/2	Framing Plan & Details
E-1/2	Electrical Plans

**A-2.1**  
Lower Level Structural Plan



# MAIN LEVEL NOTES:

DIMENSIONS ARE FROM CENTER OF INTERIOR WALLS / EXTERIOR FACE OF STUD WALL.

- TYPICAL PLATE HEIGHT TO BE 10'-1 1/8"  
- PLATE HEIGHT TO BE 12'-1 1/8" IN THE STAIRS / KITCHEN / DINING / & GREAT ROOM.

- TYPICAL WINDOW HEADER TO BE 2-2X12'S UNLESS NOTED OTHERWISE.  
- TYPICAL ROUGH HEADER HEIGHT TO BE 8'-9 3/8" OFF ROUGH FLR.

- AT KITCHEN / DINING / GREAT ROOM:

- ROUGH HEADER HEIGHT TO BE 10'-9 3/8"  
- 1-3/4" LVL HORIZ. FRAMING BETWEEN TRANSOM AND WDW/DR BELOW SET BOT. AT 8'-6 1/4" OFF ROUGH FLR.

- PROVIDE SPACE TO ACCOMMODATE 5/16" BASE AND 3/16" CASING.  
- WINDOW GRIDS TO BE BETWEEN GLASS.  
- SOUND REDUCING INSULATION AT ALL BATH AND LAUNDRY WALLS.  
- BATH DOOR TO HAVE SELF-CLOSING HINGE.

REVIEW BRACED WALL PLAN LOCATED AT THE END OF THE SET FOR STRUCTURAL PANEL & MOMENT FRAMING LOCATIONS/DETAILS

1-3/4" X 14" LVL FRAMING RIP TO 12, 318"  
SLOPED AT 1/4" / 12" - NOTCH OUT FOR 2X8

1-3/4" X 20" LVL

2X12

2X12 FRAMING

2X12 FRAMING SISTERED ONTO TRUSSES  
10'-0" - 10'-3" LENGTH TO BLOCKING

30' - 5 1/2"

W14X68 STL BEAM

1-3/4" X 20" LVL

1-3/4" X 14" LVL

1-3/4" X 11-1/4" LVL


1-3/4" X 16" LVL

1-3/4" X 11-1/4" LVL

1-3/4" X 11-1/4" LVL

1-3/4" X 11-1/4" LVL

1-3/4" X 11-1/4" LVL

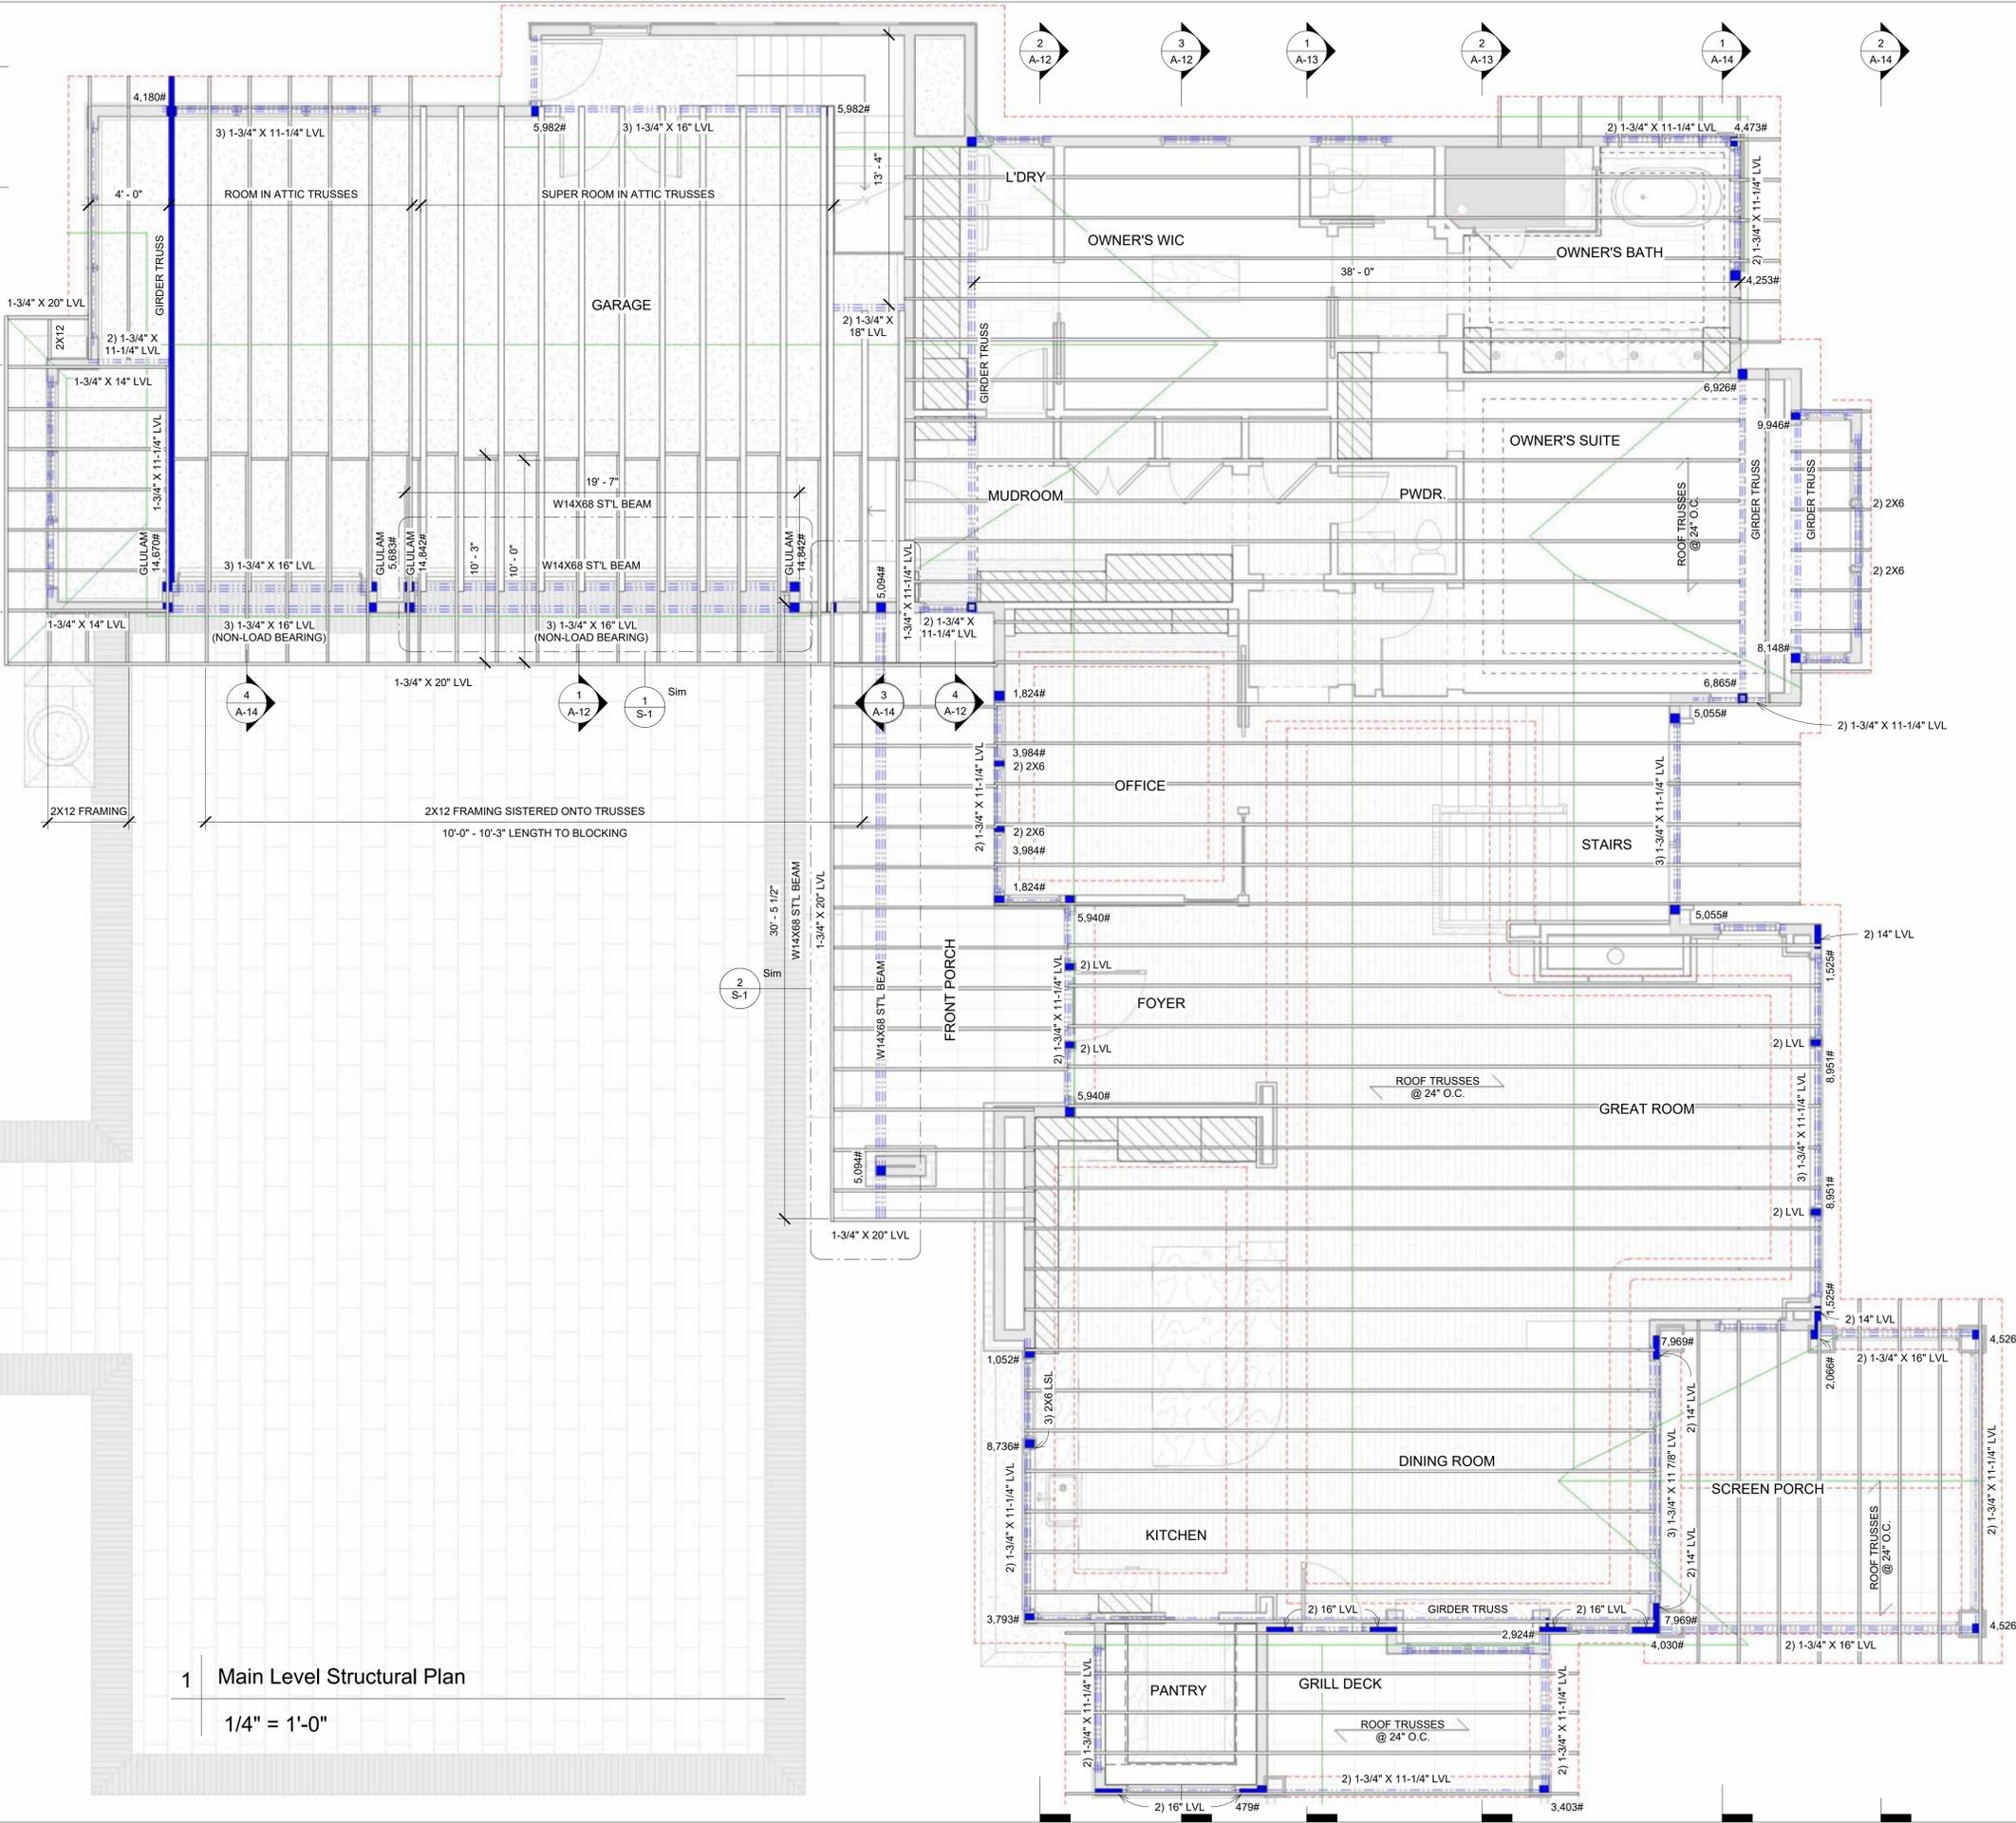

1 Main Level Structural Plan

1/4" = 1'-0"

**CHARLES CUDDOO.**  
ARCHITECTURAL DESIGN • BUILD  
15000 23rd Ave. N. • Plymouth, MN 55447 • 612-333-8020 Phone  
charlescuddoo.com

© Charles Cuddoo Co.  
THESE PLANS AND THE WORK CONSTRUCTED PURSUANT TO THEM ARE THE SOLE PROPERTY OF CHARLES CUDDOO ARCHITECTURAL DESIGN • BUILD. NO PART OF THESE PLANS OR THE WORK SHALL BE REPRODUCED OR TRANSMITTED IN ANY FORM OR BY ANY MEANS, ELECTRONIC OR MECHANICAL, WITHOUT THE WRITTEN PERMISSION OF CHARLES CUDDOO ARCHITECTURAL DESIGN • BUILD. COPYRIGHT © 2023

HEREBY CERTIFY THAT THIS PLAN WAS PREPARED BY ME OR UNDER MY CLOSE PERSONAL SUPERVISION AND TO THE BEST OF MY KNOWLEDGE AND BELIEF IT COMPLIES WITH ALL CITY, STATE AND FEDERAL REQUIREMENTS UNDER THE LAWS OF THE STATE OF MINNESOTA.  
DATE: \_\_\_\_\_  
SIGN: \_\_\_\_\_  
REG. NO: \_\_\_\_\_

RESIDENCE FOR: **Pleasant View Model**  
935 Pleasant View Rd, Chamhassen  
ADDRESS: MN 55317  
LOT No.: \_\_\_\_\_  
PROJECT: Custom Home  
JOB No.: 1050101

Revision #	Schedule	Description	Date

DATE DRAWN: 02/28/26  
CUSTOMER: TBD  
PLAN REVIEW: TBD  
RELEASE: Approver  
DRAWN BY: Author

**SHEET INDEX**


T-1	Title
T-2/5	Exterior Perspectives
A-1	Foundation Plan
A-2	Lower Level Finish Plan
A-3	Main Level Floor Plan
A-4	Front Elevation
A-5	Right Elevation
A-6	Left Elevation
A-7	Rear Elevation & Roof
A-8/10	Building Sections
A-11	Wall Sections
I-1/3	Interior Elevations
S-1/2	Framing Plan & Details
E-1/2	Electrical Plans

**A-3.1**  
Main Level Structural Plan

# UPPER LEVEL NOTES:

DIMENSIONS ARE FROM CENTER OF INTERIOR WALLS / EXTERIOR FACE OF STUD WALL.

- TYPICAL PLATE HEIGHT TO VARY W/ VAULTED CEILING - SEE SECTIONS
- TYPICAL WINDOW HEADER TO BE 2-2X12'S UNLES NOTED OTHERWISE.
- TYPICAL ROUGH HEADER HEIGHT TO BE 4' - 8 3/8" OFF ROUGH FLR.
- PROVIDE SPACE TO ACCOMMODATE 5 1/4" BASE AND 3 1/3" CASING.
- WINDOW GRIDS TO BE BETWEEN GLASS.

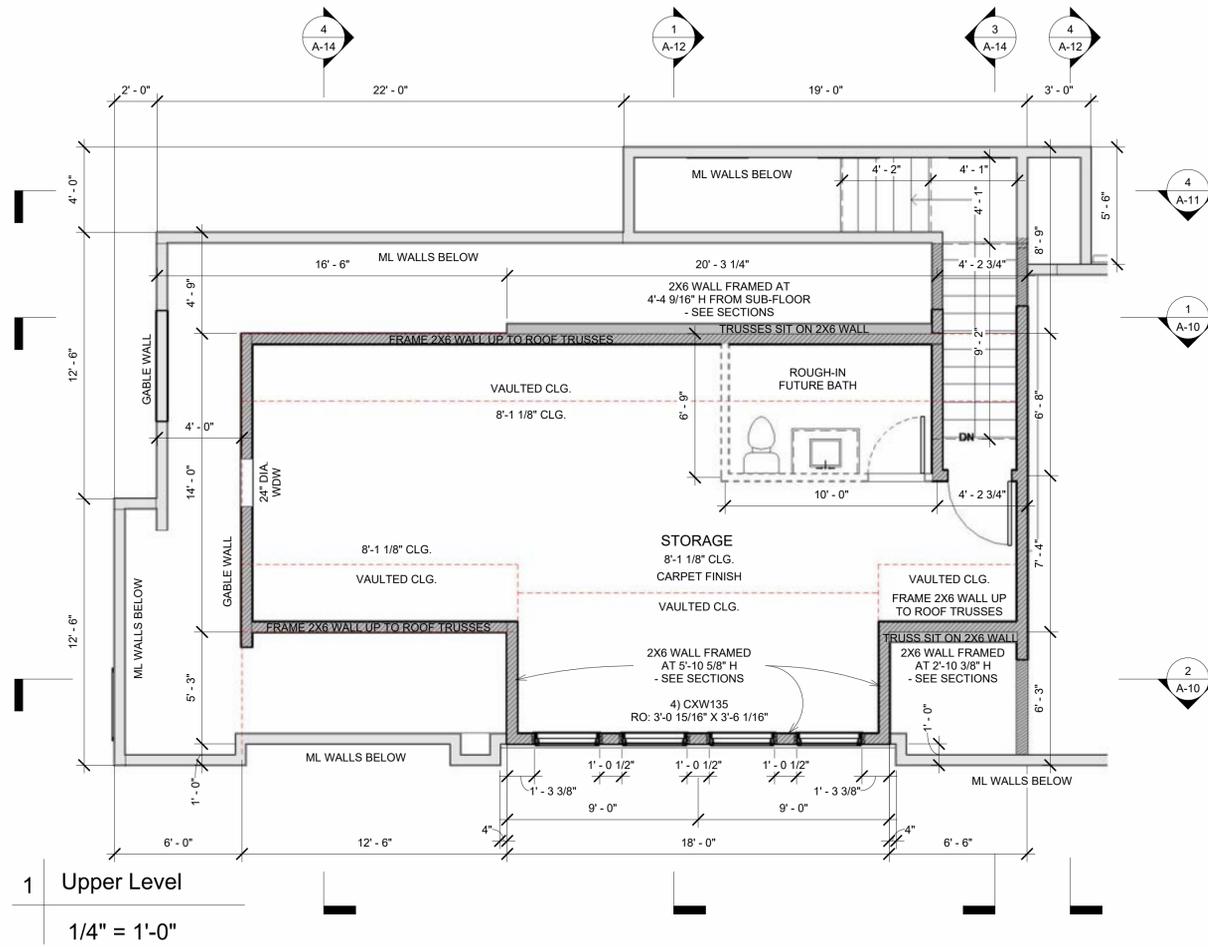

**CHARLES CUDDOO.**  
ARCHITECTURAL DESIGN • BUILD  
15000 23rd Ave. N. • Plymouth, MN 55447 • 612-333-8020 Phone  
charlescuddoo.com

© Charles Cudd Co.  
THESE PLANS AND THE WORK CONSTRUCTED PURSUANT TO THEM ARE THE SOLE PROPERTY OF CHARLES CUDDOO ARCHITECTURAL DESIGN • BUILD. NO PART OF THESE PLANS OR THE WORK SHALL BE REPRODUCED OR TRANSMITTED IN ANY FORM OR BY ANY MEANS, ELECTRONIC OR MECHANICAL, INCLUDING PHOTOCOPYING, RECORDING, OR BY ANY INFORMATION STORAGE AND RETRIEVAL SYSTEM, WITHOUT THE WRITTEN PERMISSION OF CHARLES CUDDOO ARCHITECTURAL DESIGN • BUILD. COPYRIGHT © 2023

I HEREBY CERTIFY THAT THESE PLANS WERE PREPARED BY ME OR UNDER MY CLOSE PERSONAL SUPERVISION AND THAT I AM A LICENSED ARCHITECT UNDER THE LAWS OF THE STATE OF MINNESOTA.  
DATE: \_\_\_\_\_  
SIGN: \_\_\_\_\_  
REG. NO: \_\_\_\_\_

RESIDENCE FOR: **Pleasant View Model**  
935 Pleasant View Rd, Chamhassen  
ADDRESS: MN 55317  
LOT No.: \_\_\_\_\_  
PROJECT: Custom Home  
JOB No.: 1050101


Revision Schedule		
#	Description	Date

DATE DRAWN: 02/17/26  
CUSTOMER: TBD  
PLAN REVIEW: TBD  
RELEASE: Approver  
DRAWN BY: Author

**SHEET INDEX**


T-1	Title
T-2/5	Exterior Perspectives
A-1	Foundation Plan
A-2	Lower Level Finish Plan
A-3	Main Level Floor Plan
A-4	Front Elevation
A-5	Right Elevation
A-6	Left Elevation
A-7	Rear Elevation & Roof
A-8/10	Building Sections
A-11	Wall Sections
I-1/3	Interior Elevations
S-1/2	Framing Plan & Details
E-1/2	Electrical Plans

**A-4**  
Upper Level

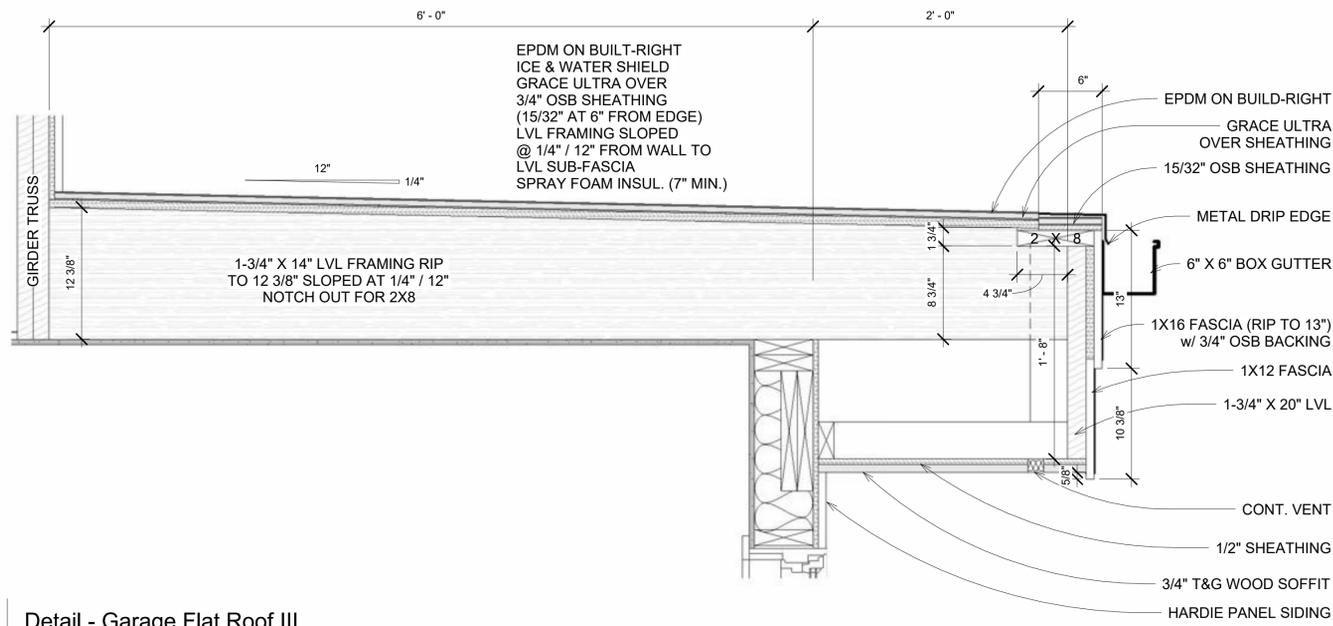

2 Detail - Garage Flat Roof III

1 1/2" = 1'-0"

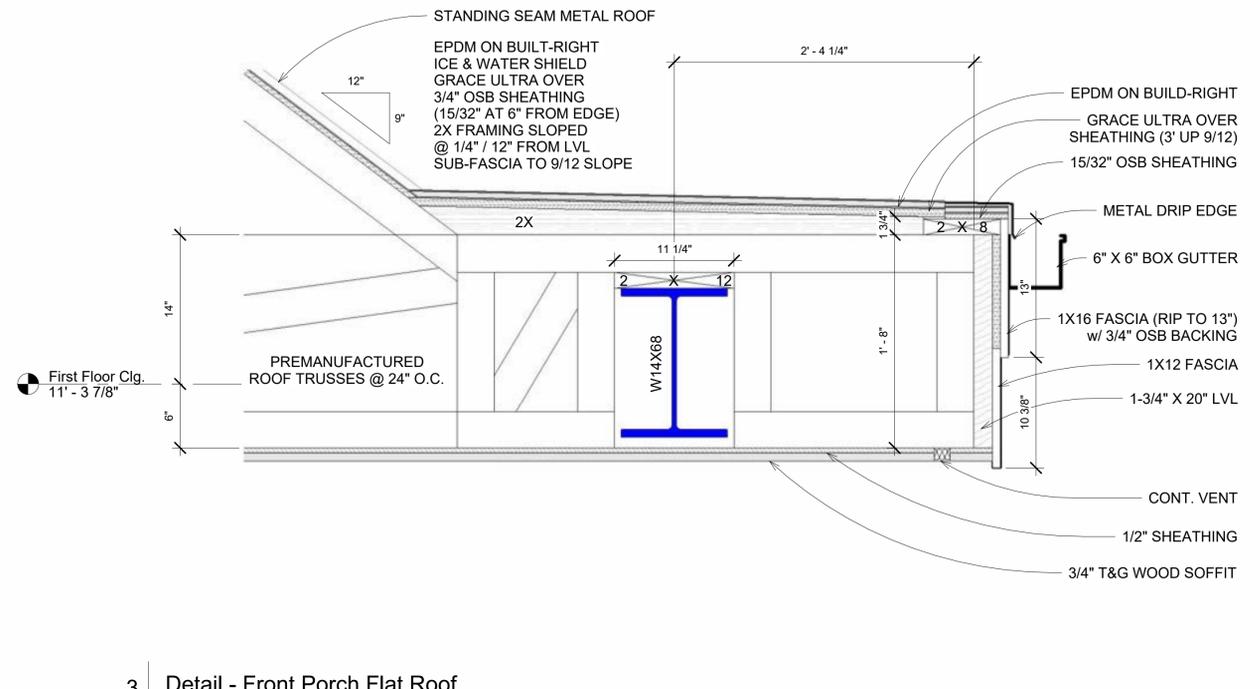

3 Detail - Front Porch Flat Roof

1 1/2" = 1'-0"




1 Front Elevation

1/4" = 1'-0"

Revision Schedule		
#	Description	Date


DATE DRAWN: 05/09/23	CUSTOMER: TBD	PLAN REVIEW: TBD	RELEASE: Approver	DRAWN BY: Author
----------------------	---------------	------------------	-------------------	------------------

SHEET INDEX	
T-1	Title
T-2/5	Exterior Perspectives
A-1	Foundation Plan
A-2	Lower Level Finish Plan
A-3	Main Level Floor Plan
A-4	Front Elevation
A-5	Right Elevation
A-6	Left Elevation
A-7	Rear Elevation & Roof
A-8/10	Building Sections
A-11	Wall Sections
I-1/3	Interior Elevations
S-1/2	Framing Plan & Details
E-1/2	Electrical Plans

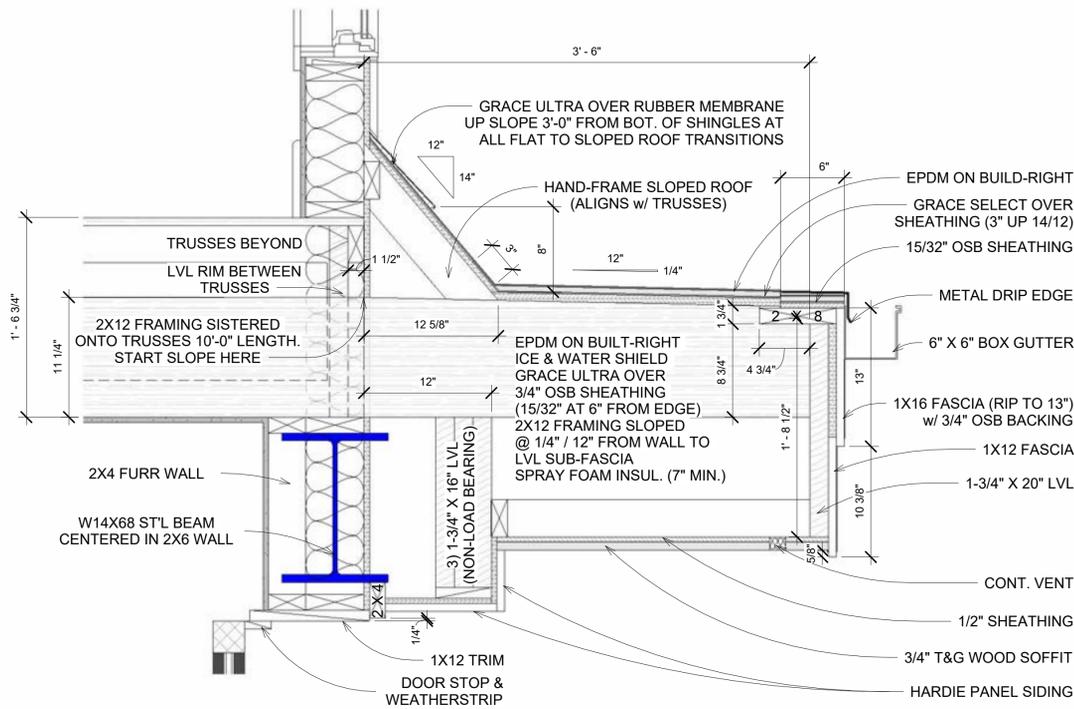

2 Detail - Garage Flat Roof I

1 1/2" = 1'-0"

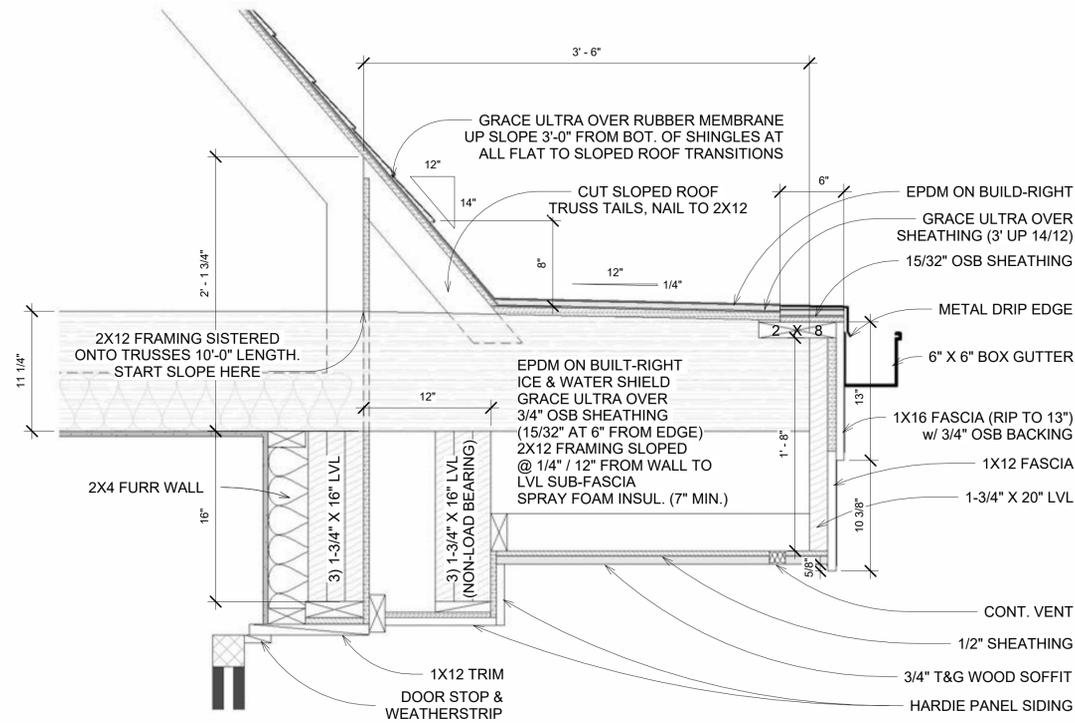

3 Detail - Garage Flat Roof II

1 1/2" = 1'-0"



1 Right Elevation




1/4" = 1'-0"

Revision Schedule		
#	Description	Date

DATE DRAWN: 05/03/23  
CUSTOMER: TBD  
PLAN REVIEW: TBD  
RELEASE: Approver  
DRAWN BY: Author

**SHEET INDEX**

- T-1 Title
- T-2/5 Exterior Perspectives
- A-1 Foundation Plan
- A-2 Lower Level Finish Plan
- A-3 Main Level Floor Plan
- A-4 Front Elevation
- A-5 Right Elevation
- A-6 Left Elevation
- A-7 Rear Elevation & Roof
- A-8/10 Building Sections
- A-11 Wall Sections
- I-1/3 Interior Elevations
- S-1/2 Framing Plan & Details
- E-1/2 Electrical Plans

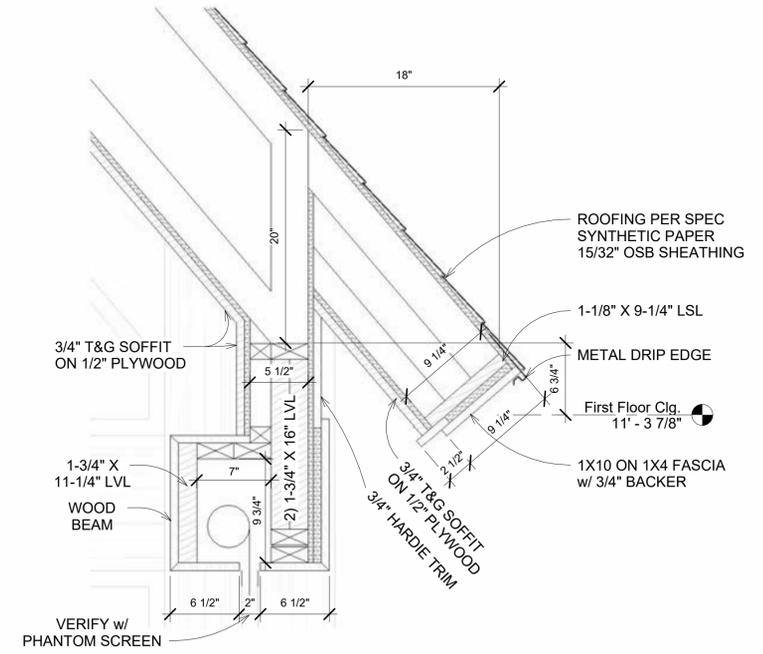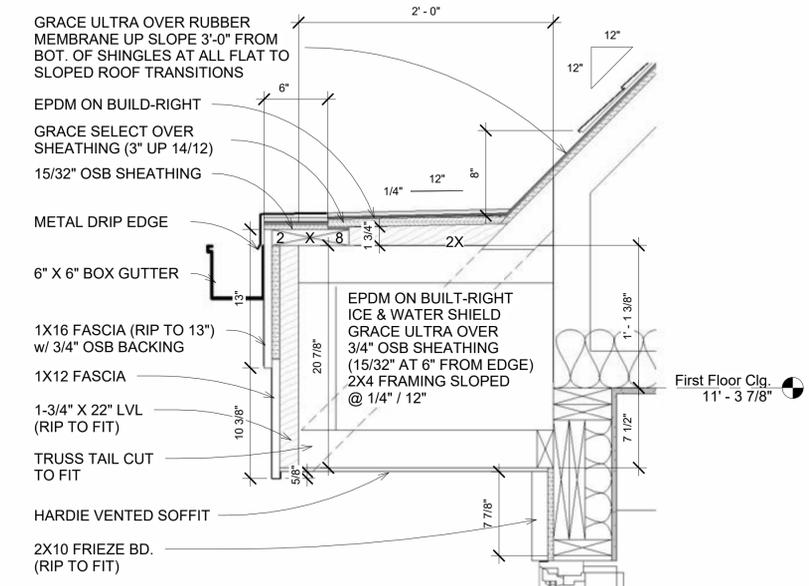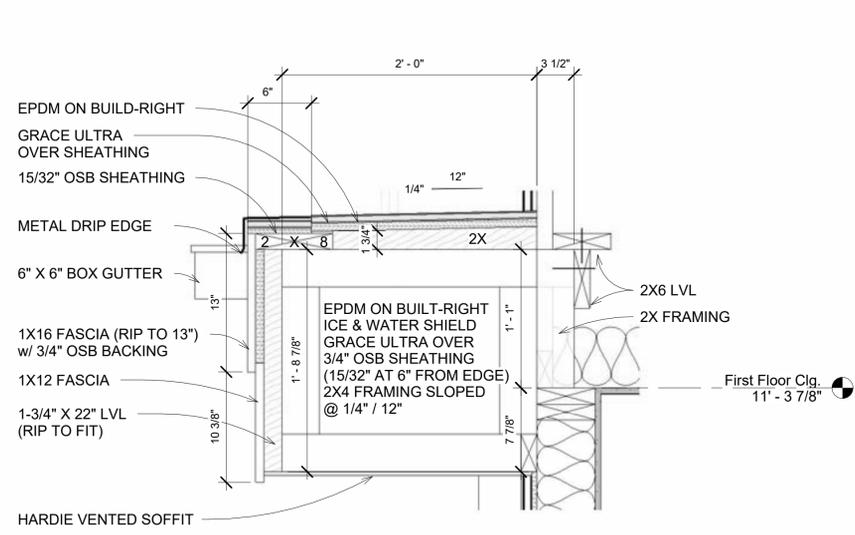

2 Detail - Owner's Bath Flat Roof I

1 1/2" = 1'-0"

3 Detail - Owner's Bath Flat Roof II

1 1/2" = 1'-0"

4 Detail - Porch Tipped Eave

1 1/2" = 1'-0"



1 Left Elevation

1/4" = 1'-0"

**CHARLES CUDDOO**  
ARCHITECTURAL DESIGN • BUILD  
15030 23rd Ave. N. • Plymouth, MN 55447 • 612-333-8020 Phone  
charlescuddoo.com

© Charles Cuddoo Co.  
THESE PLANS AND THE WORK CONSTRUCTED PURSUANT TO THEM ARE THE SOLE PROPERTY OF CHARLES CUDDOO ARCHITECTURAL DESIGN • BUILD. NO PART OF THESE PLANS OR THE WORK SHALL BE REPRODUCED OR TRANSMITTED IN ANY FORM OR BY ANY MEANS, ELECTRONIC OR MECHANICAL, WITHOUT THE WRITTEN PERMISSION OF CHARLES CUDDOO ARCHITECTURAL DESIGN • BUILD. COPYRIGHT © 2023

I HEREBY CERTIFY THAT THIS PLAN WAS PREPARED BY ME OR UNDER MY CLOSE PERSONAL SUPERVISION AND THAT I AM A LICENSED ARCHITECT UNDER THE LAWS OF THE STATE OF MINNESOTA  
DATE: \_\_\_\_\_  
SIGN: \_\_\_\_\_  
REG. NO: \_\_\_\_\_

RESIDENCE FOR: **Pleasant View Model**  
935 Pleasant View Rd, Chamhassen  
ADDRESS: MN 55317  
LOT No.: \_\_\_\_\_  
PROJECT: Custom Home  
JOB No.: 1050101

Revision Schedule	
#	Date


DATE DRAWN: 02/16/26  
CUSTOMER: TBD  
PLAN REVIEW: TBD  
RELEASE: Approver  
DRAWN BY: Author

**SHEET INDEX**

T-1	Title
T-2/5	Exterior Perspectives
A-1	Foundation Plan
A-2	Lower Level Finish Plan
A-3	Main Level Floor Plan
A-4	Front Elevation
A-5	Right Elevation
A-6	Left Elevation
A-7	Rear Elevation & Roof
A-8/10	Building Sections
A-11	Wall Sections
I-1/3	Interior Elevations
S-1/2	Framing Plan & Details
E-1/2	Electrical Plans


**A-7**  
Left Elevation



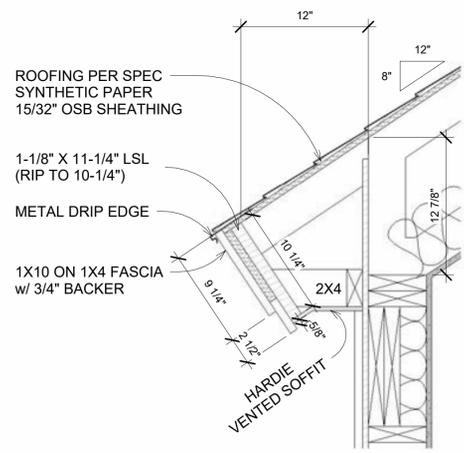


4 Detail - Garage Tipped Eave II

1 1/2" = 1'-0"

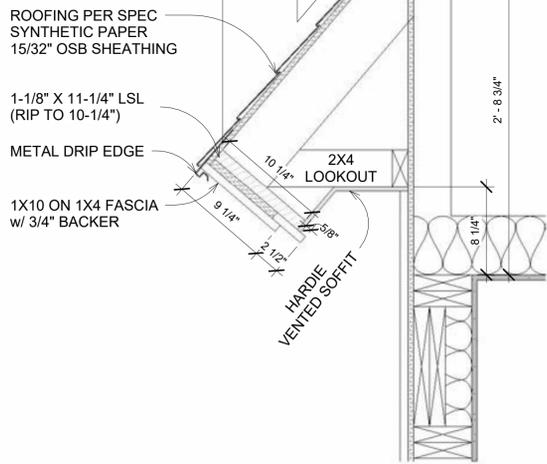


2 Detail - Garage Tipped Eave I

1 1/2" = 1'-0"

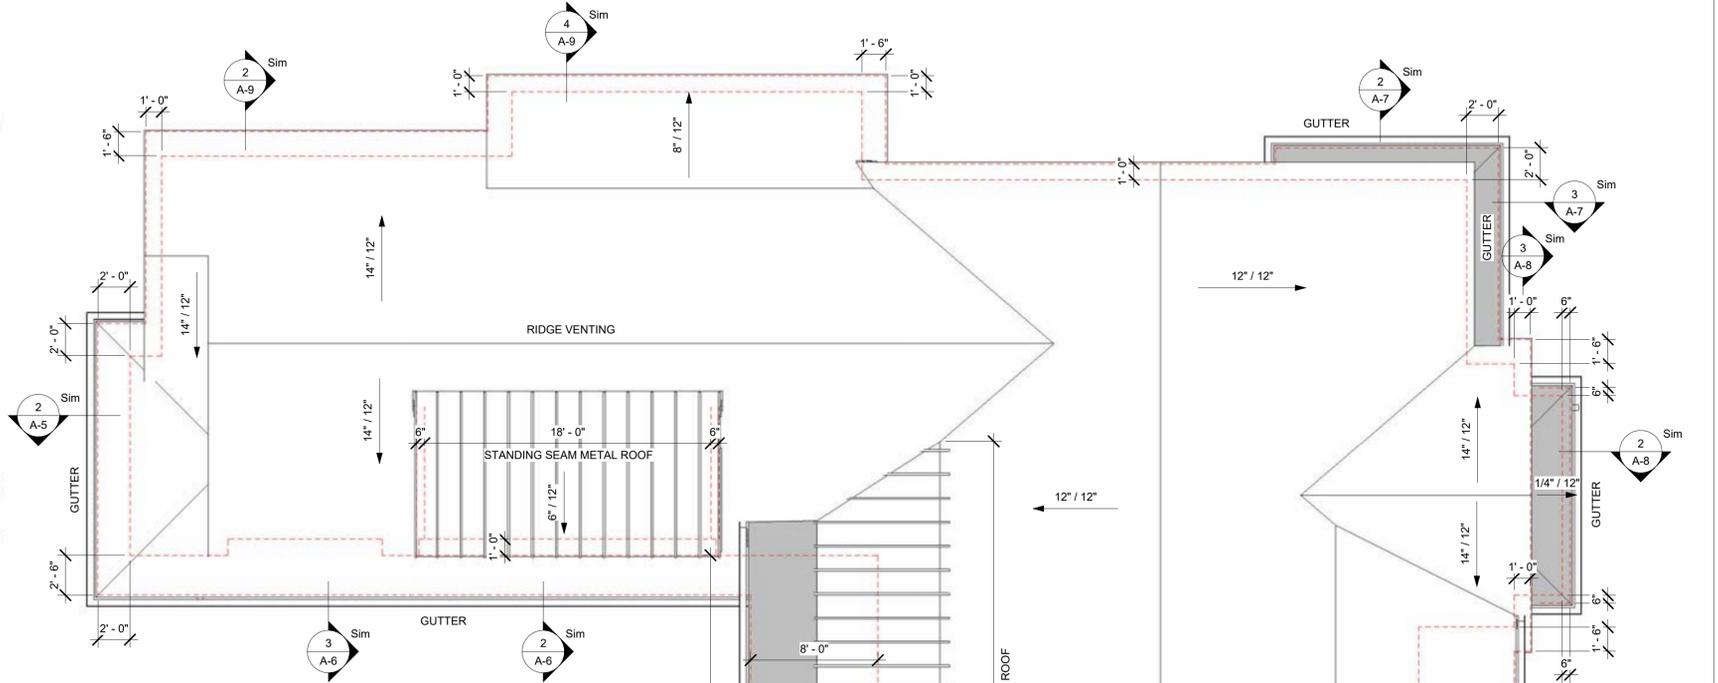


1 Roof Plan

3/16" = 1'-0"

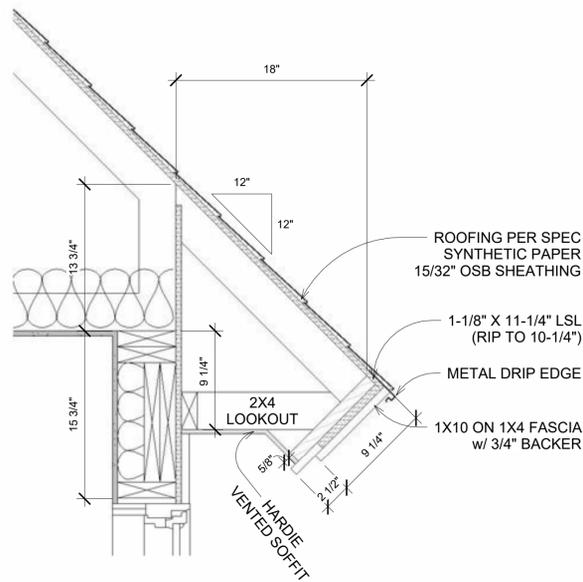

3 Detail - Pantry Tipped Eave II

1 1/2" = 1'-0"

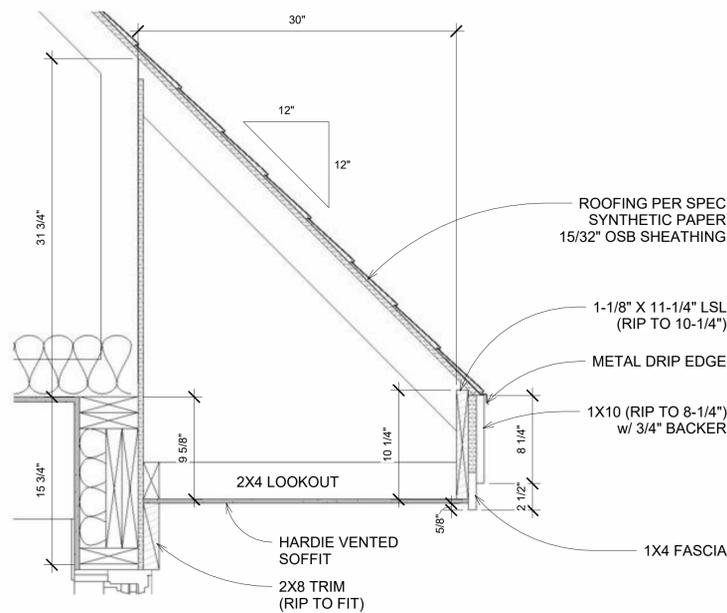

5 Detail - Kitchen Flat Eave

1 1/2" = 1'-0"


Revision Schedule	
#	Date

DATE DRAWN: 03/21/14	CUSTOMER: TBD	PLAN REVIEW: TBD	RELEASE: Approver	DRAWN BY: Author
----------------------	---------------	------------------	-------------------	------------------

SHEET INDEX	
T-1	Title
T-2/5	Exterior Perspectives
A-1	Foundation Plan
A-2	Lower Level Finish Plan
A-3	Main Level Floor Plan
A-4	Front Elevation
A-5	Right Elevation
A-6	Left Elevation
A-7	Rear Elevation & Roof
A-8/10	Building Sections
A-11	Wall Sections
I-1/3	Interior Elevations
S-1/2	Framing Plan & Details
E-1/2	Electrical Plans


1 Cross Section - Owner's Bath / Garage

1/4" = 1'-0"

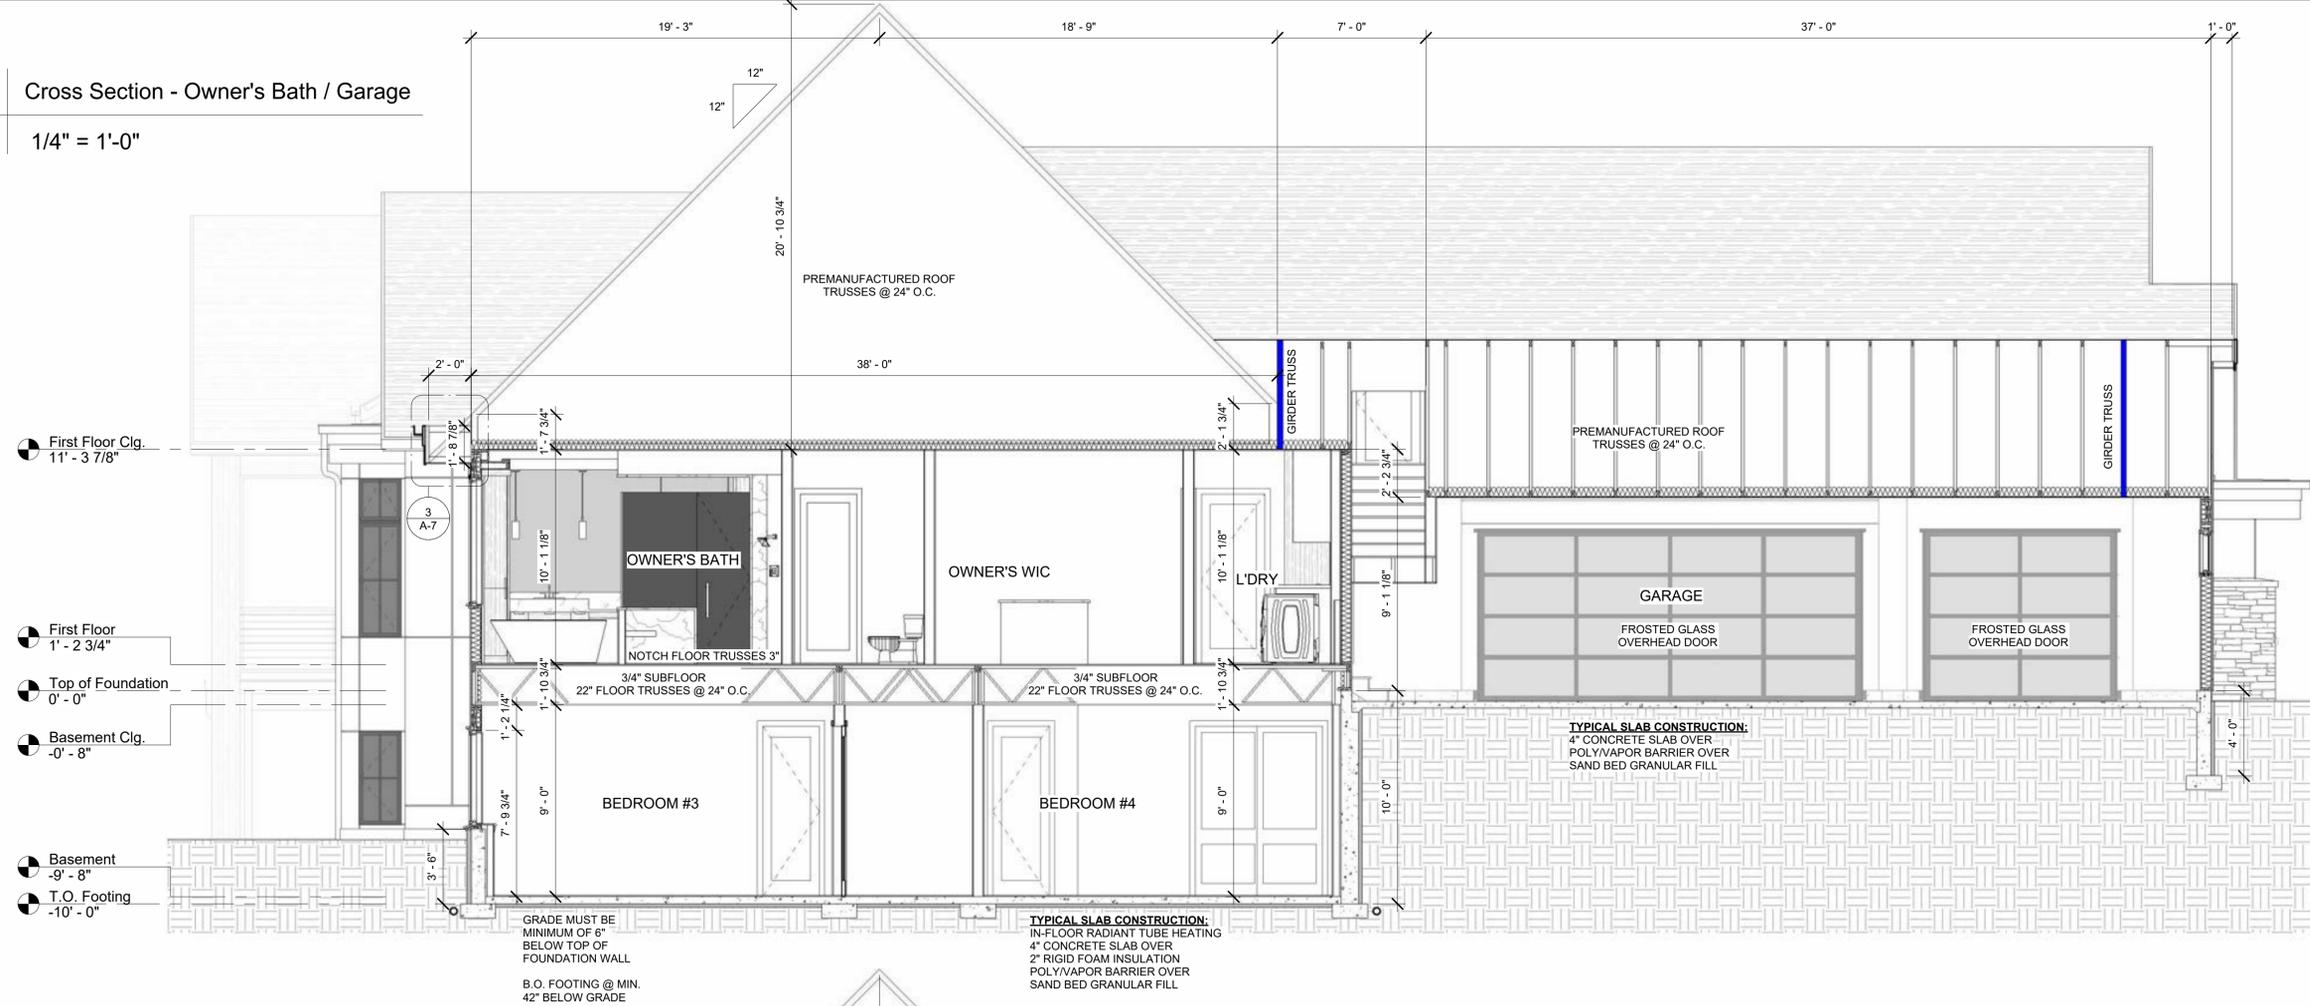

2 Cross Section - Owner's Suite / Mudroom

1/4" = 1'-0"

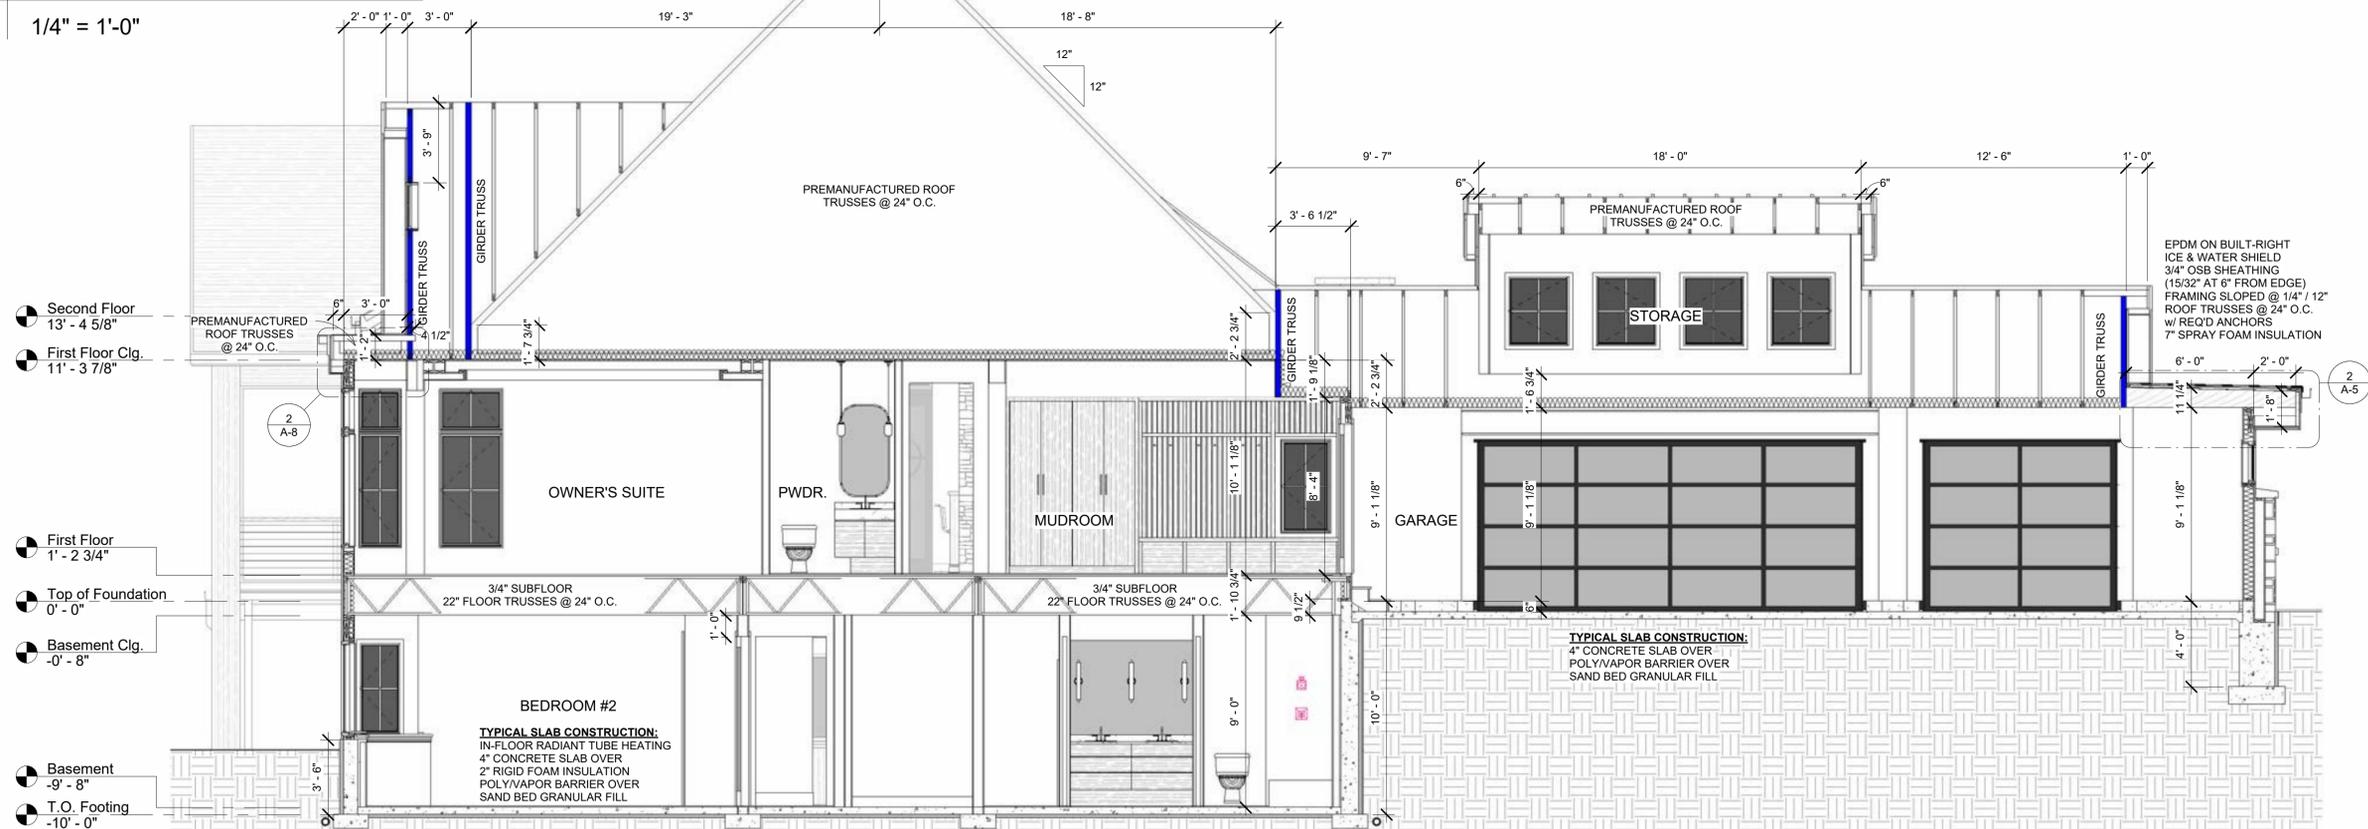


Revision Schedule	
#	Description / Date


DATE DRAWN: 11/05/21  
CUSTOMER: TBD  
PLAN REVIEW: Approver  
RELEASE: Approver  
DRAWN BY: Author

**SHEET INDEX**

- T-1 Title
- T-2/5 Exterior Perspectives
- A-1 Foundation Plan
- A-2 Lower Level Finish Plan
- A-3 Main Level Floor Plan
- A-4 Front Elevation
- A-5 Right Elevation
- A-6 Left Elevation
- A-7 Rear Elevation & Roof
- A-8/10 Building Sections
- A-11 Wall Sections
- I-1/3 Interior Elevations
- S-1/2 Framing Plan & Details
- E-1/2 Electrical Plans

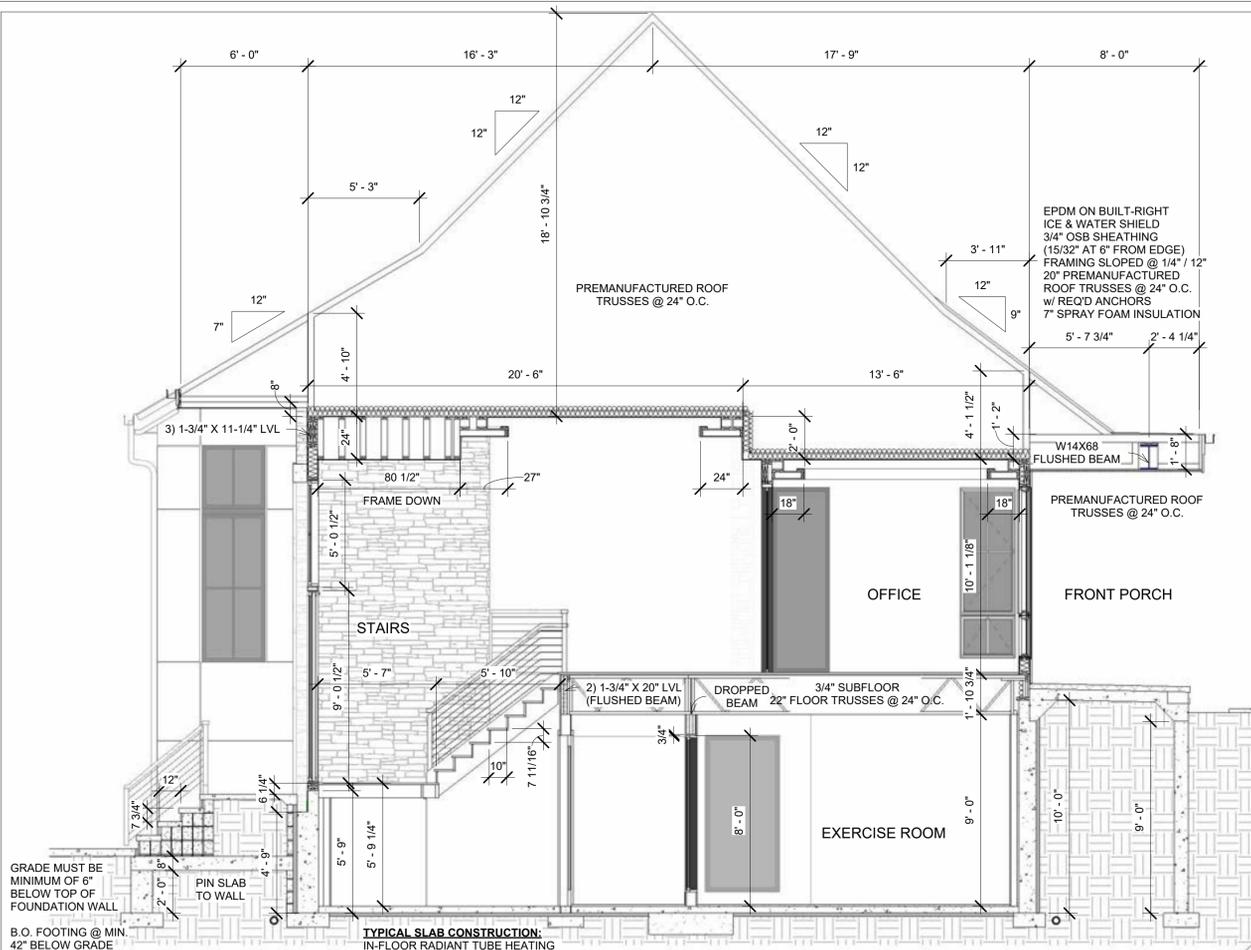


1 Cross Section - Stairs / Office  
1/4" = 1'-0"


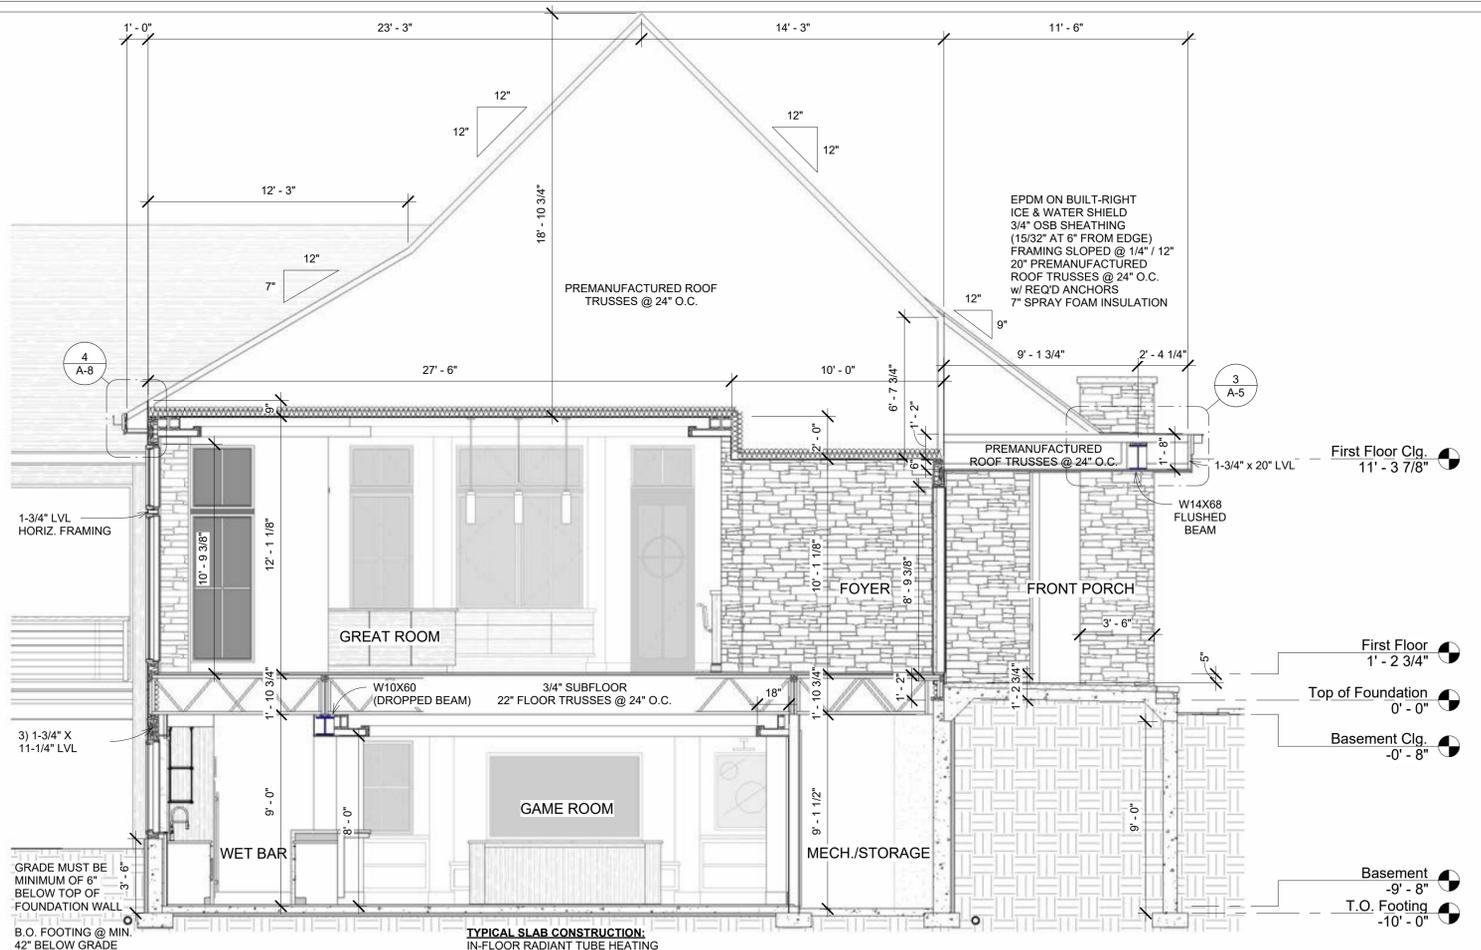


2 Cross Section - Great Room / Foyer  
1/4" = 1'-0"

3 Cross Section - Screen Porch / Dining  
1/4" = 1'-0"

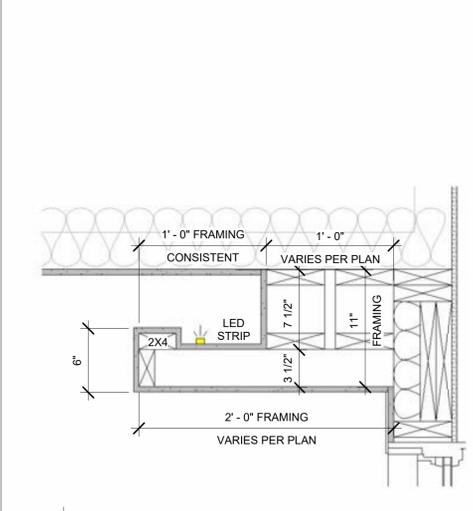

5 Detail - ML Soffit  
1 1/2" = 1'-0"

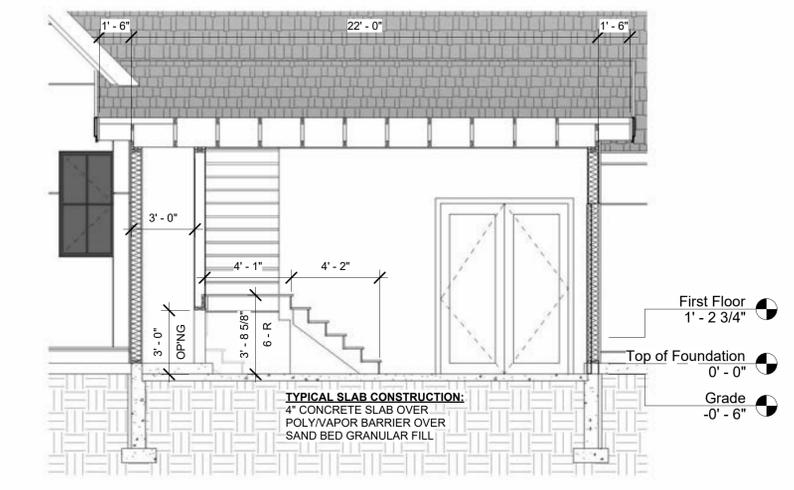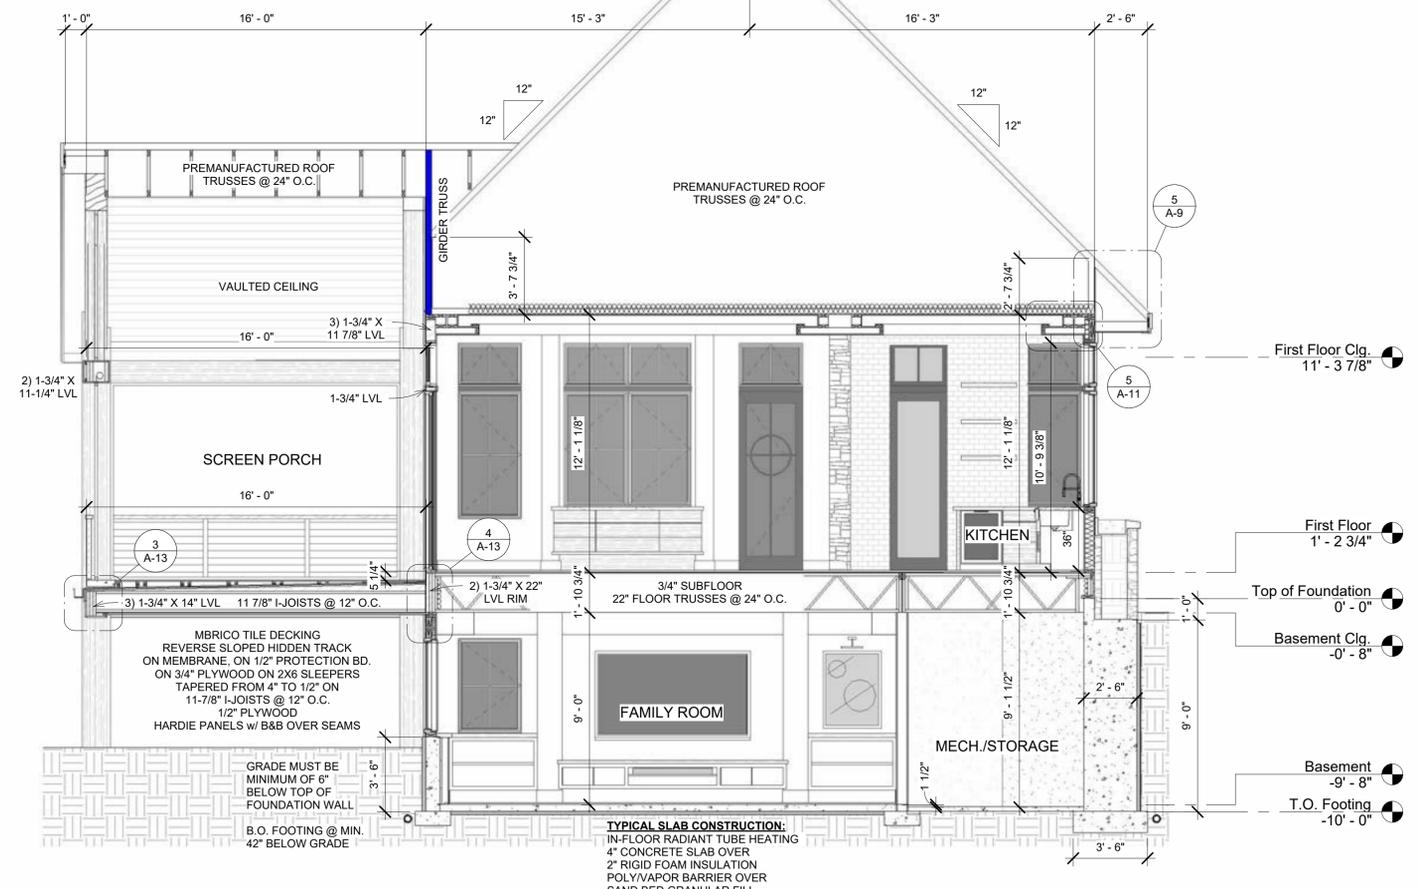


4 Cross Section - Garage II  
1/4" = 1'-0"

Revision Schedule	Description	Date
#		

DATE DRAWN: 11/05/21	CUSTOMER: TBD	PLAN REVIEW: TBD	RELEASE: Approver	DRAWN BY: Author
----------------------	---------------	------------------	-------------------	------------------

**SHEET INDEX**

- T-1 Title
- T-2/5 Exterior Perspectives
- A-1 Foundation Plan
- A-2 Lower Level Finish Plan
- A-3 Main Level Floor Plan
- A-4 Front Elevation
- A-5 Right Elevation
- A-6 Left Elevation
- A-7 Rear Elevation & Roof
- A-8/10 Building Sections
- A-11 Wall Sections
- I-1/3 Interior Elevations
- S-1/2 Framing Plan & Details
- E-1/2 Electrical Plans

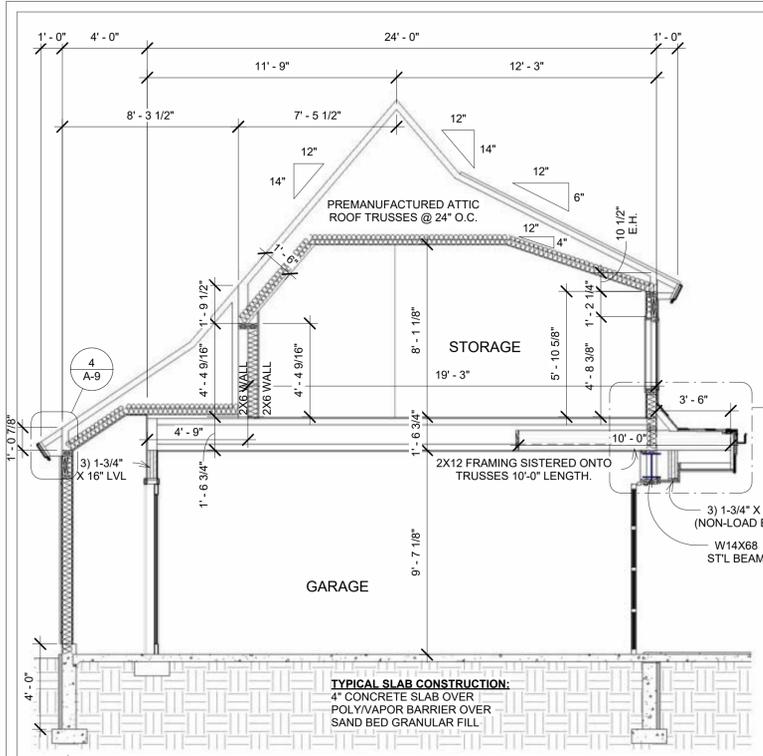

1 Cross Section - Garage

1/4" = 1'-0"

2 Cross Section - L'dry / Foyer / Kitchen


1/4" = 1'-0"

3 Cross Section - Office / Foyer / Kitchen

1/4" = 1'-0"

4 Cross Section - L'dry / Mudroom

1/4" = 1'-0"

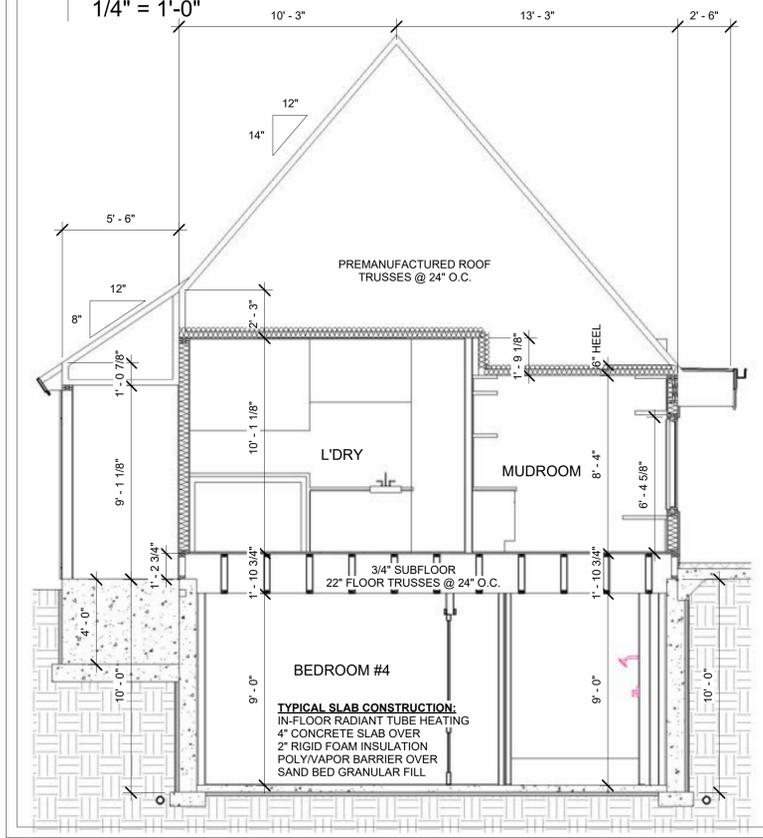

Roof Peak  
32' - 2 5/8"

First Floor Clg.  
11' - 3 7/8"



First Floor  
1' - 2 3/4"

Top of Foundation  
0' - 0"

Basement Clg.  
-0' - 8"

Basement  
-9' - 8"

T.O. Footing  
-10' - 0"

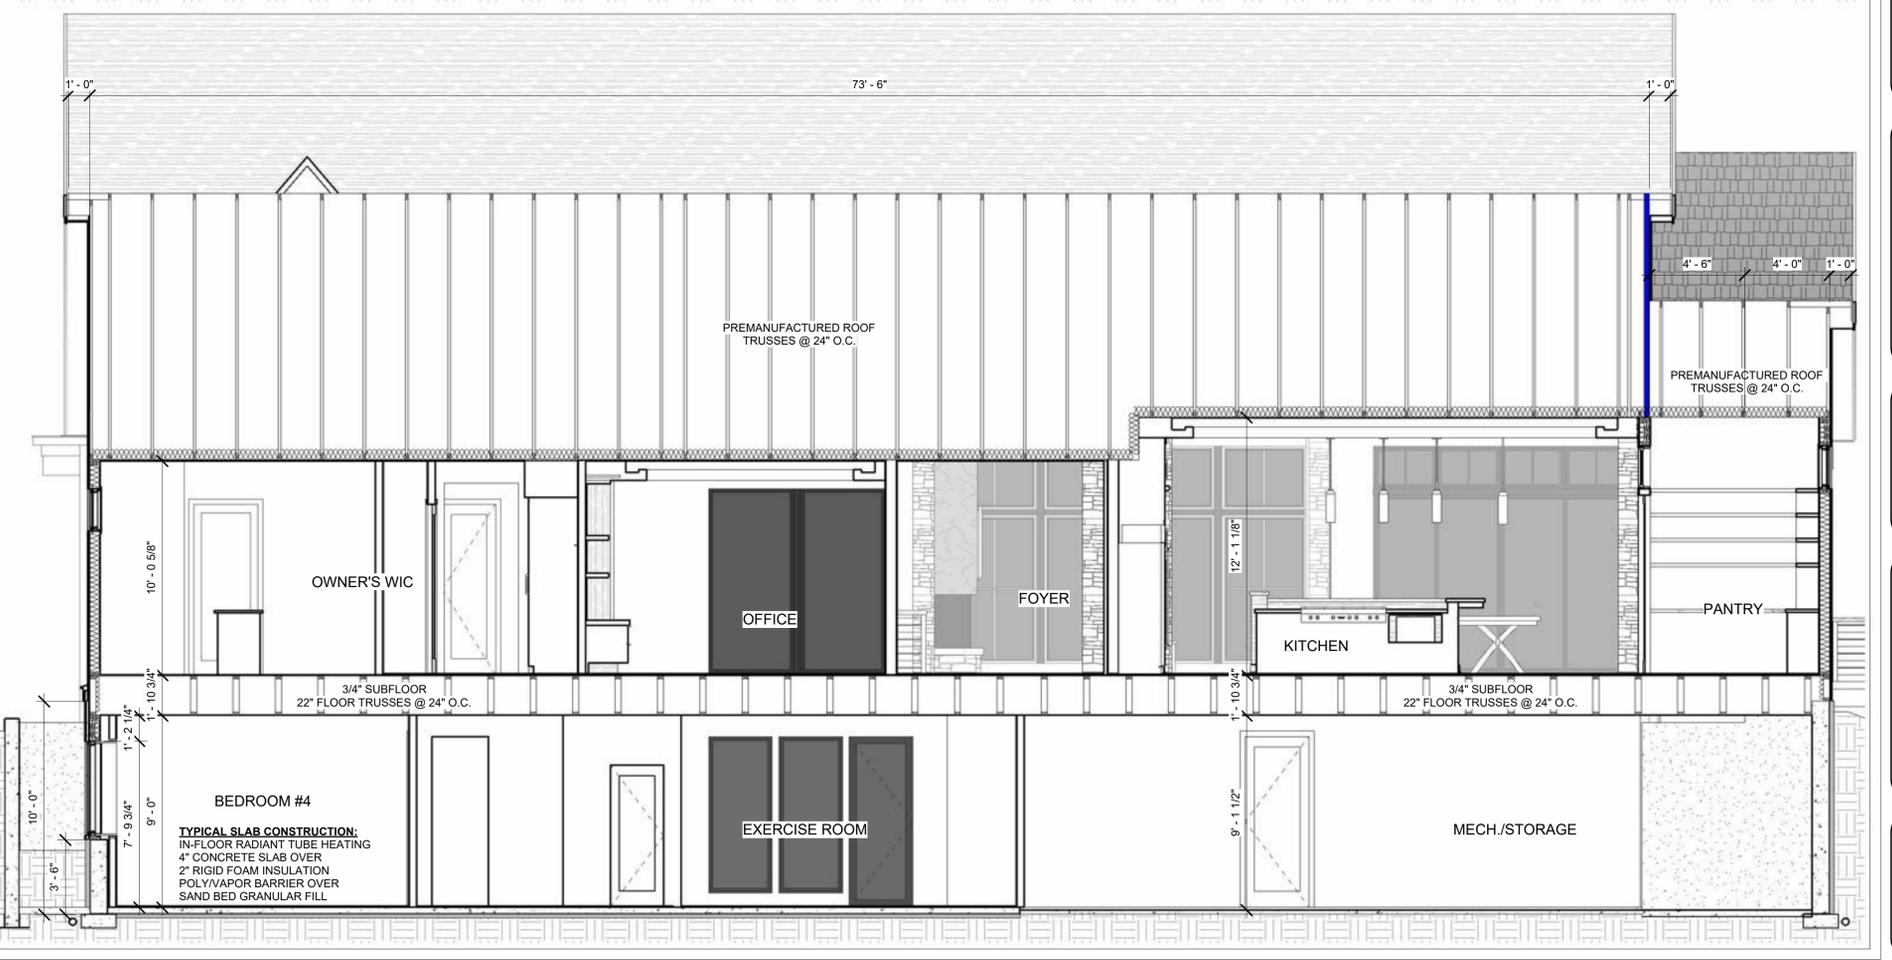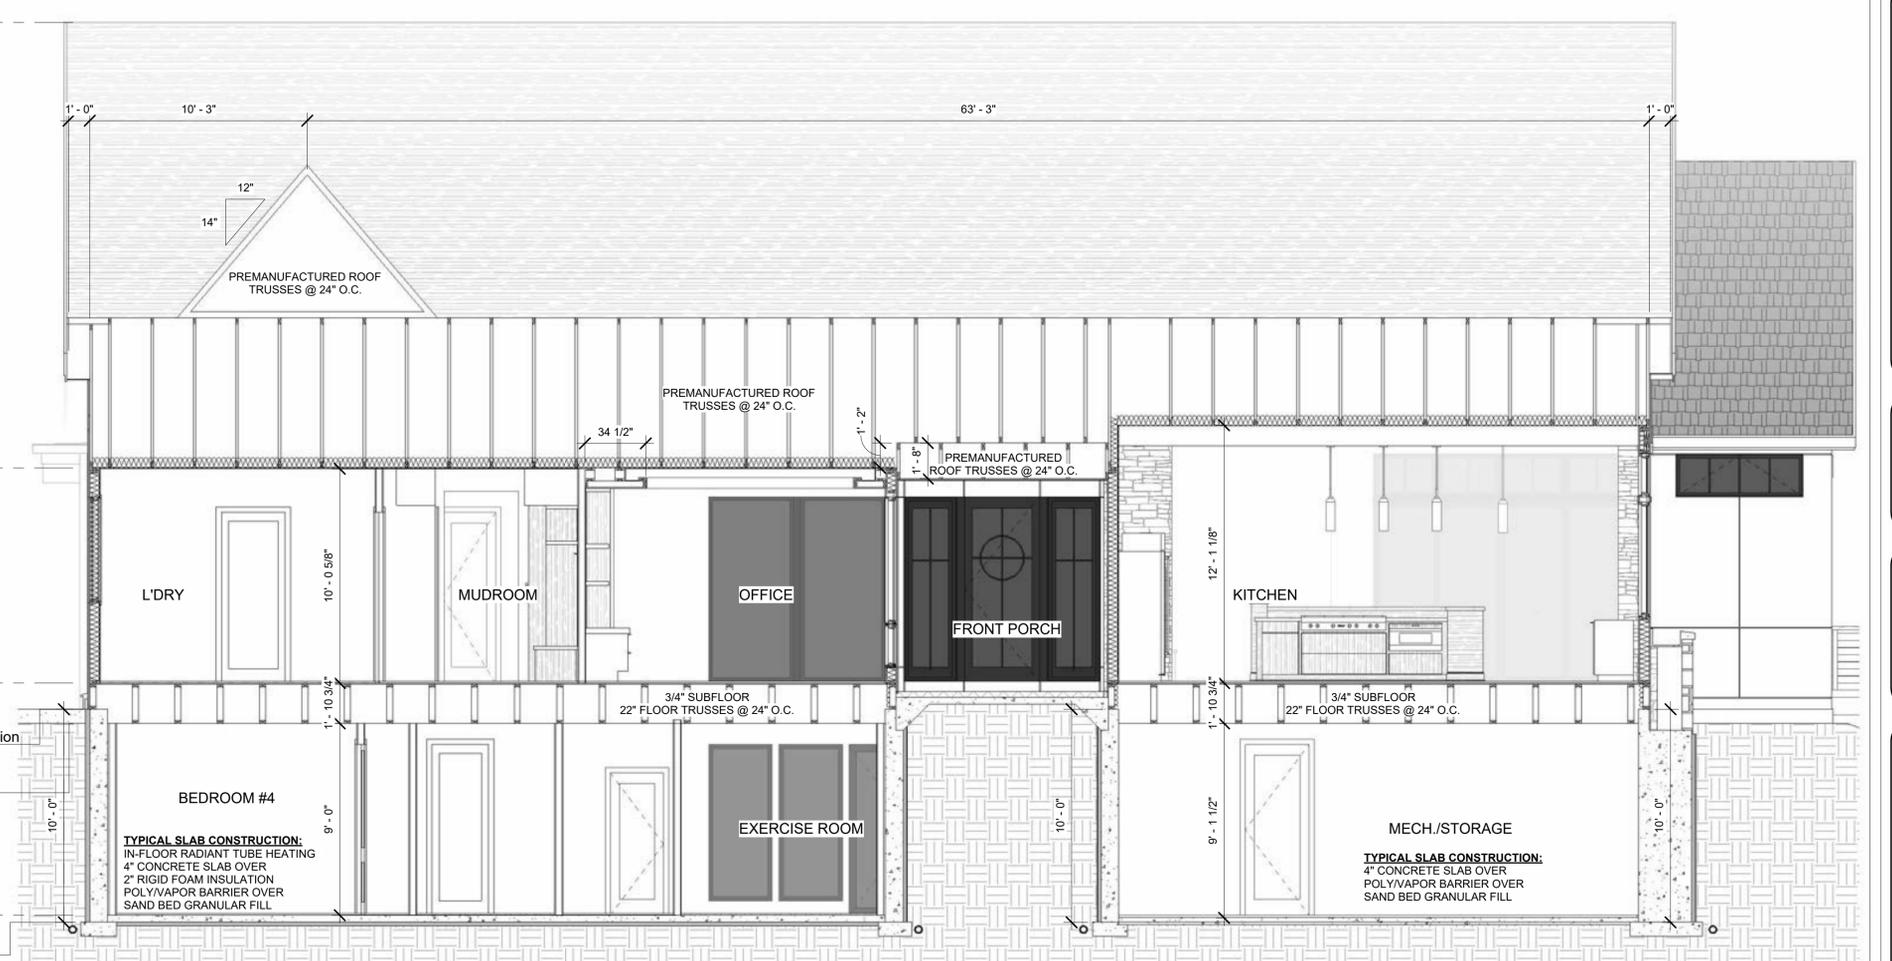


Revision Schedule	
#	Date

DATE DRAWN: 11/05/21	CUSTOMER: TBD	PLAN REVIEW: TBD	RELEASE: Approver	DRAWN BY: Author
----------------------	---------------	------------------	-------------------	------------------

SHEET INDEX	
T-1	Title
T-2/5	Exterior Perspectives
A-1	Foundation Plan
A-2	Lower Level Finish Plan
A-3	Main Level Floor Plan
A-4	Front Elevation
A-5	Right Elevation
A-6	Left Elevation
A-7	Rear Elevation & Roof
A-8/10	Building Sections
A-11	Wall Sections
I-1/3	Interior Elevations
S-1/2	Framing Plan & Details
E-1/2	Electrical Plans


1 Cross Section - Great Room / Dining Room / Grill Deck

1/4" = 1'-0"

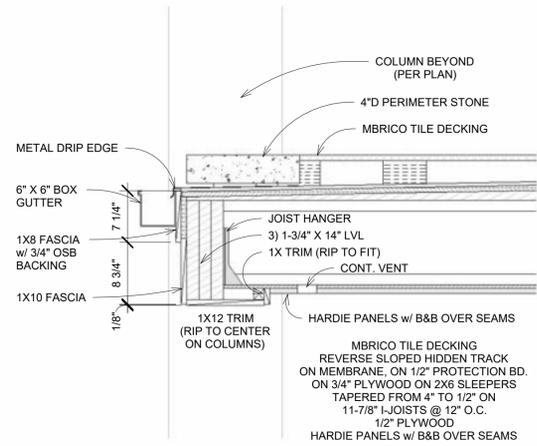


3 Detail - Deck

1" = 1'-0"

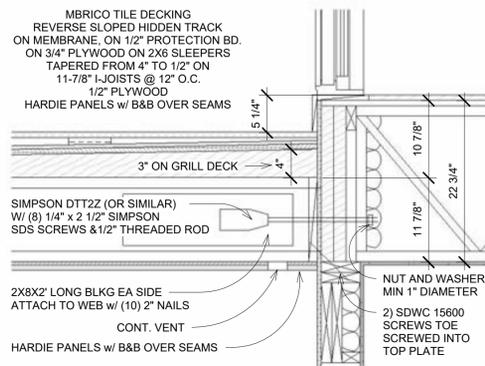


4 Detail - Deck/House

1" = 1'-0"

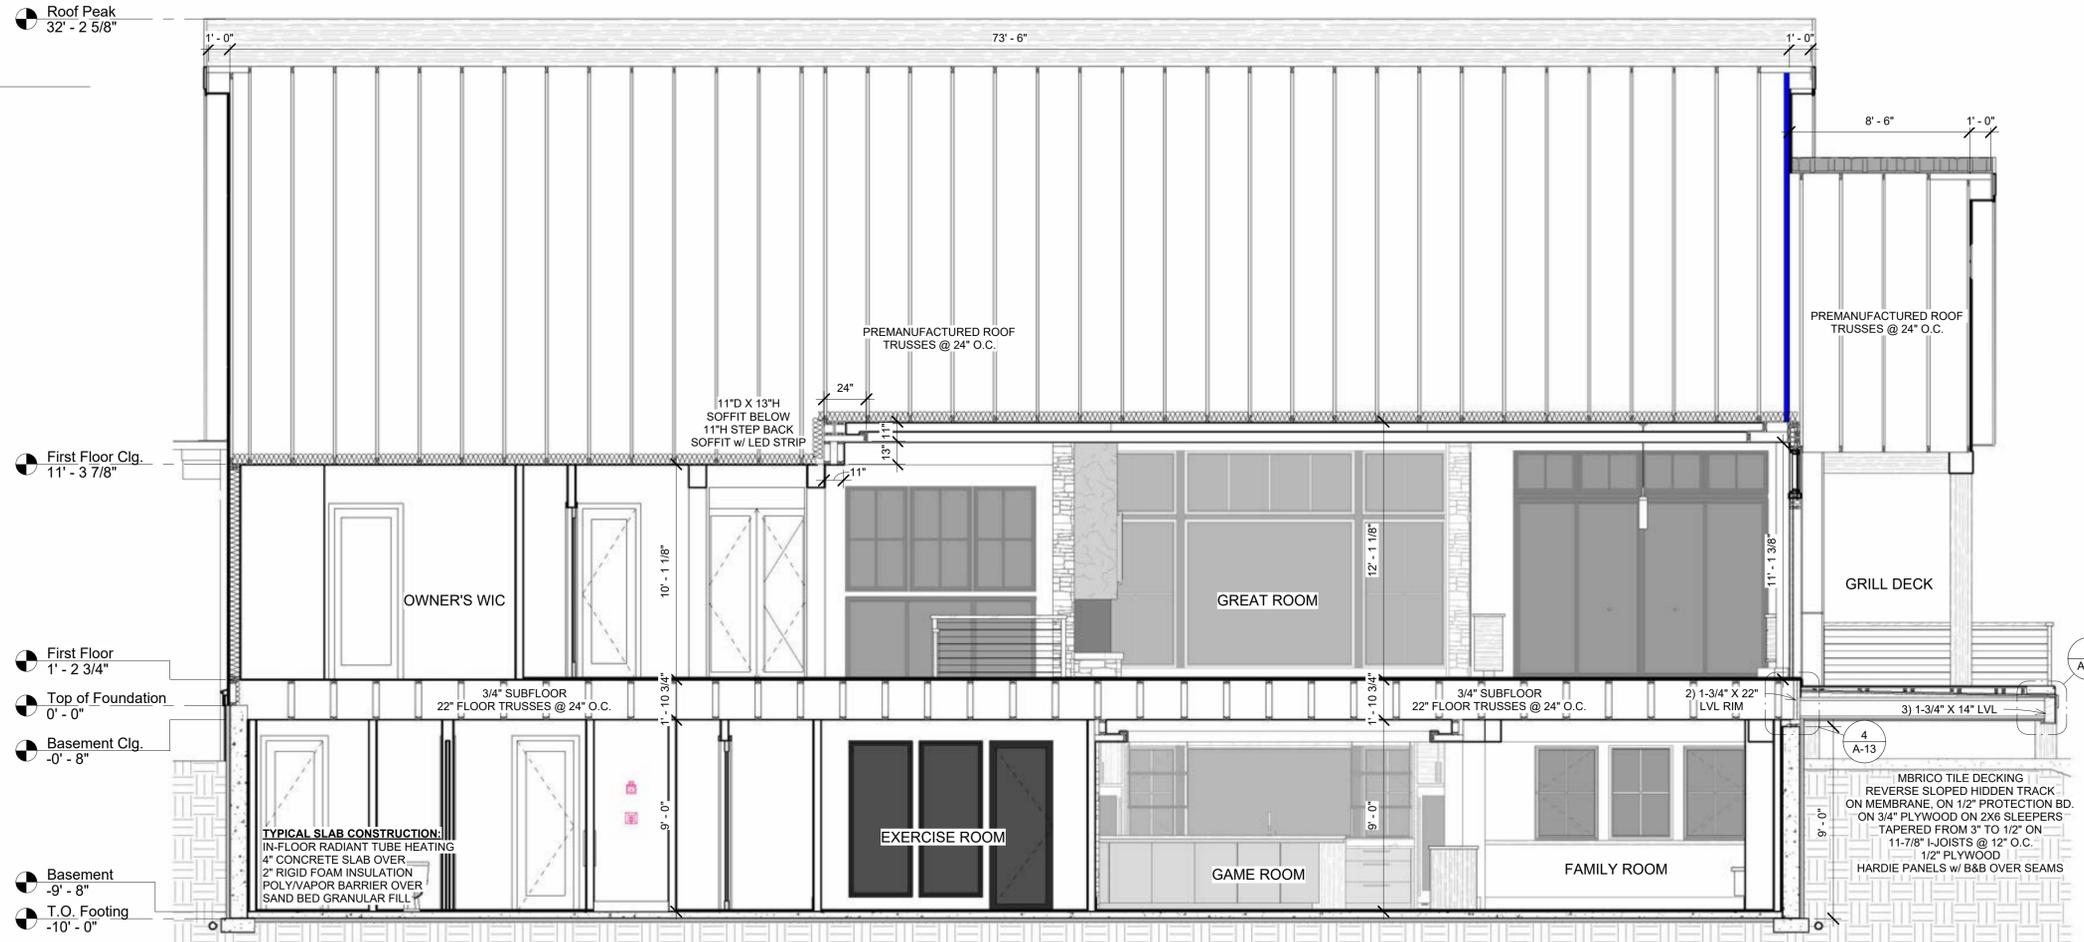

2 Cross Section - Owner's Suite / Stairs / Great Room

1/4" = 1'-0"

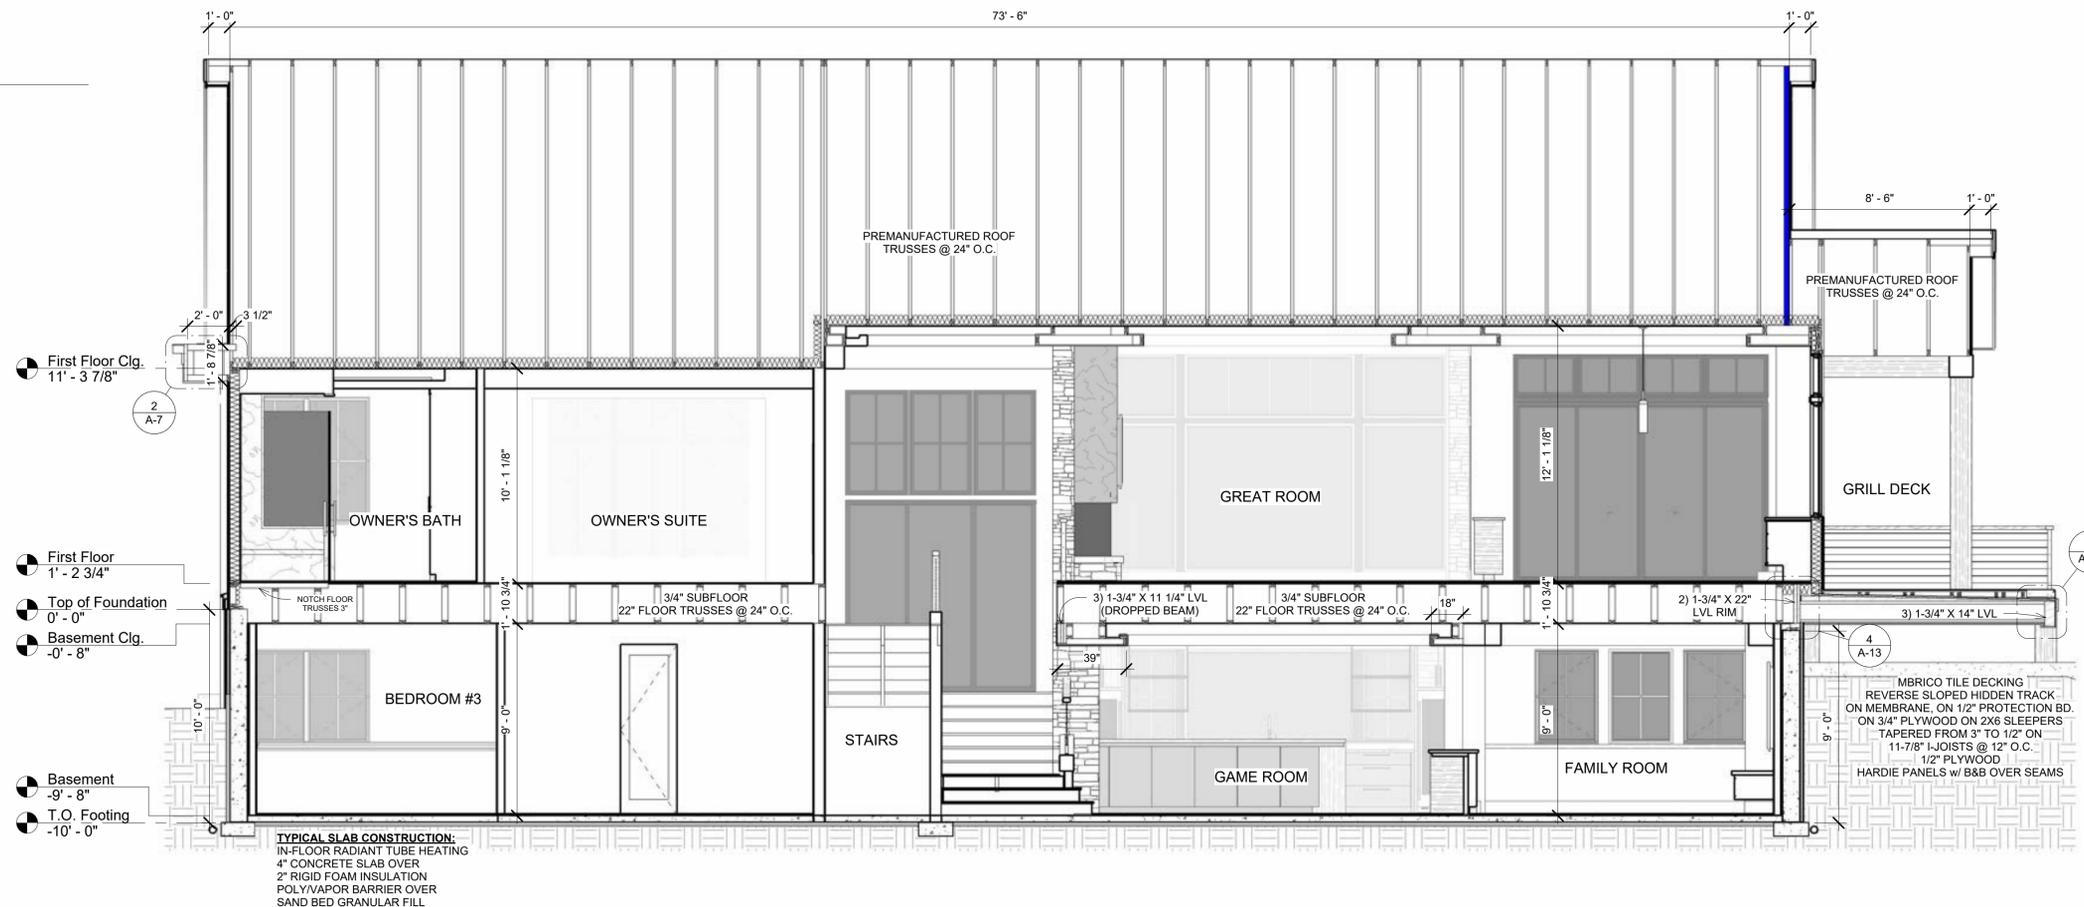

**CHARLES CUDDOO**  
 ARCHITECTURAL DESIGN • BUILD

15000 23rd Ave. N. • Plymouth, MN 55447 • 612-333-8020 Phone  
 charlescuddoo.com

© Charles Cuddoo  
 THESE PLANS AND THE WORK CONSTRUCTED PURSUANT TO THEM ARE THE SOLE PROPERTY OF CHARLES CUDDOO ARCHITECTURAL DESIGN • BUILD. NO PART OF THESE PLANS OR WORK MAY BE REPRODUCED OR TRANSMITTED IN ANY FORM OR BY ANY MEANS, ELECTRONIC OR MECHANICAL, WITHOUT PERMISSION IN WRITING FROM CHARLES CUDDOO ARCHITECTURAL DESIGN • BUILD.

HEREBY CERTIFY THAT THESE PLANS, SPECIFICATIONS AND CONTRACT DOCUMENTS WERE PREPARED BY ME OR UNDER MY CLOSE PERSONAL SUPERVISION AND TO THE BEST OF MY KNOWLEDGE AND BELIEF THEY COMPLY WITH ALL CITY, STATE AND FEDERAL REQUIREMENTS UNDER THE LAWS OF THE STATE OF MINNESOTA

DATE: \_\_\_\_\_  
 SIGN: \_\_\_\_\_  
 REG. NO: \_\_\_\_\_

RESIDENCE FOR: Pleasant View Model  
 ADDRESS: 935 Pleasant View Rd, Chanhassen MN 55317  
 LOT No.: 01 BLOCK No.: 01  
 PROJECT: Custom Home  
 JOB No.: 1050101


Revision	Schedule	Description	Date
#			

DATE DRAWN: 09/05/25  
 CUSTOMER: TBD  
 PLAN REVIEW: TBD  
 RELEASE: Approver  
 DRAWN BY: Author

**SHEET INDEX**


- T-1 Title
- T-2/5 Exterior Perspectives
- A-1 Foundation Plan
- A-2 Lower Level Finish Plan
- A-3 Main Level Floor Plan
- A-4 Front Elevation
- A-5 Right Elevation
- A-6 Left Elevation
- A-7 Rear Elevation & Roof
- A-8/10 Building Sections
- A-11 Wall Sections
- I-1/3 Interior Elevations
- S-1/2 Framing Plan & Details
- E-1/2 Electrical Plans

**A-13**  
 Building Sections

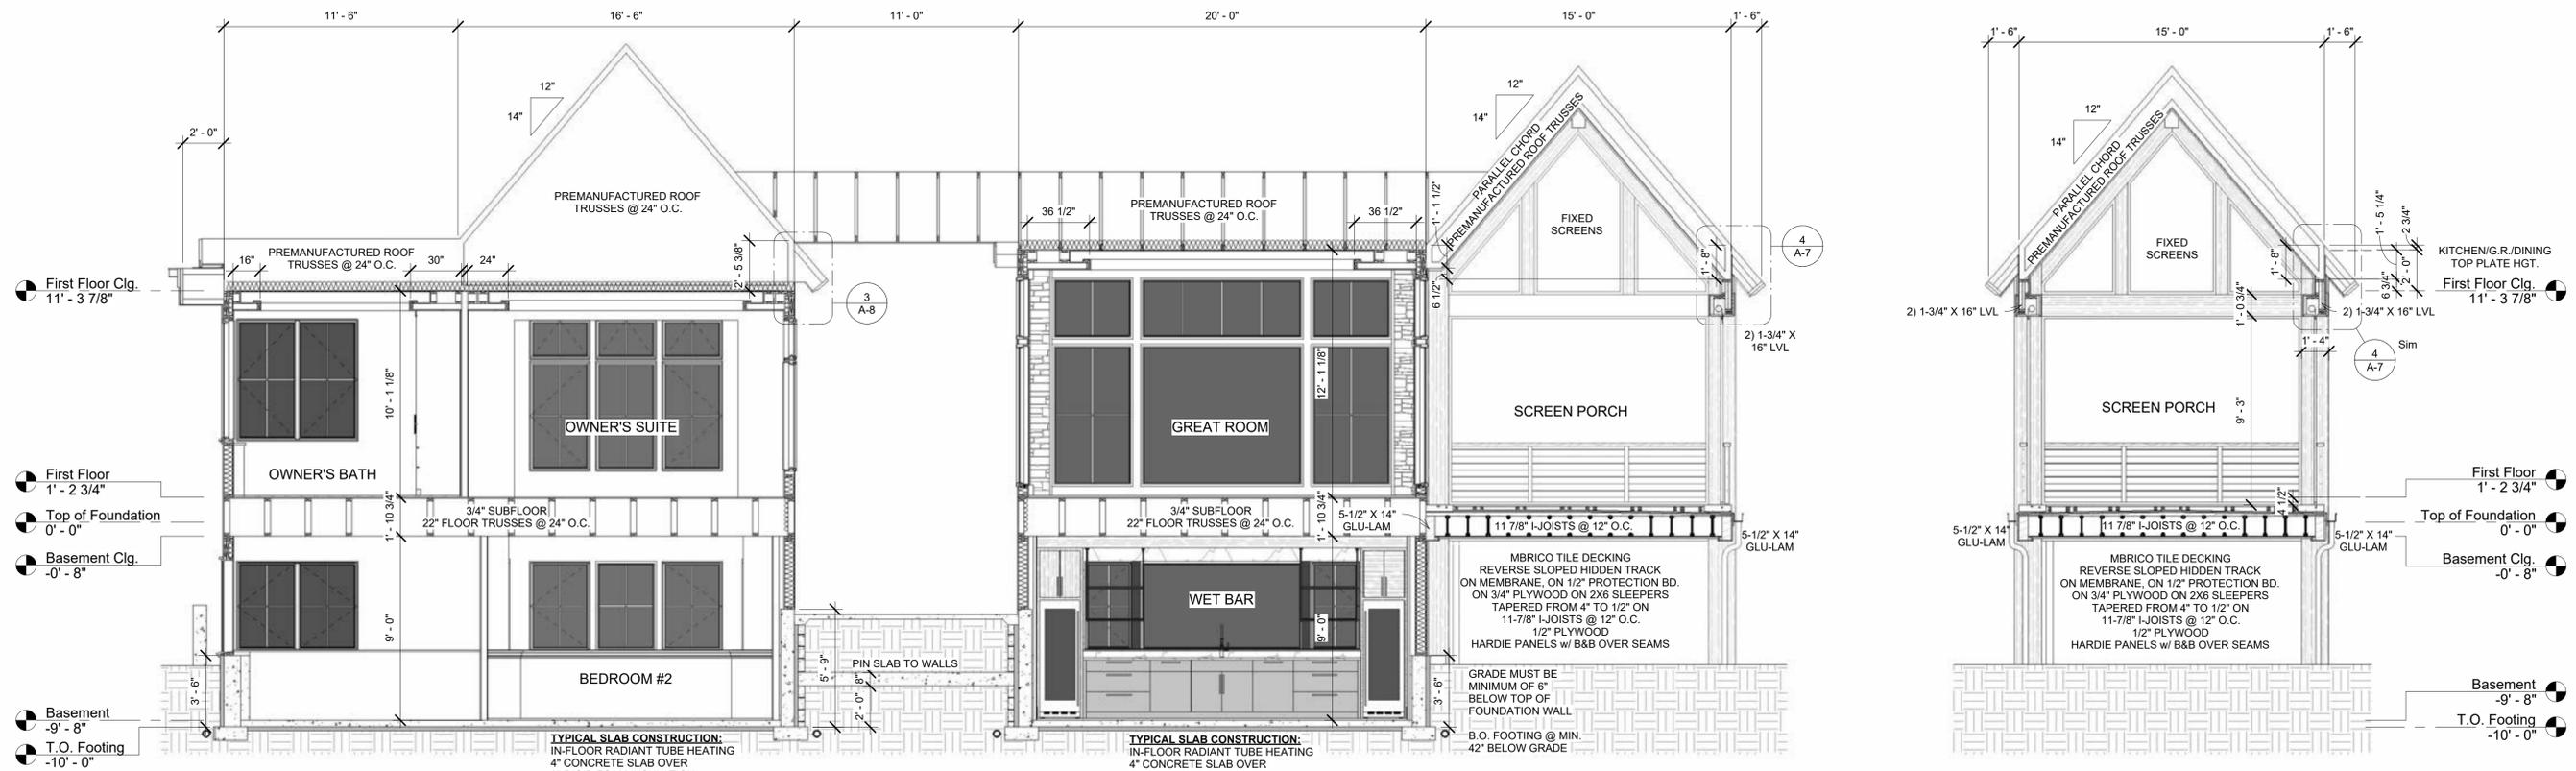


1 Cross Section - Owner's Suite / Great Room / Screen Porch

1/4" = 1'-0"

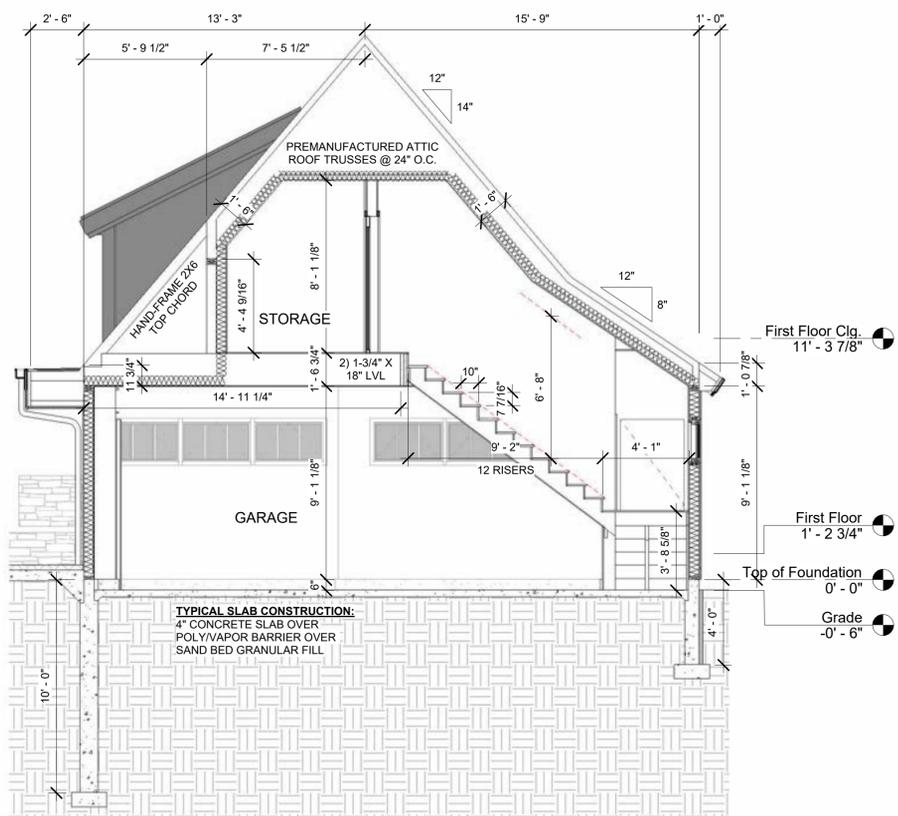


3 Cross Section - Garage / Storage

1/4" = 1'-0"

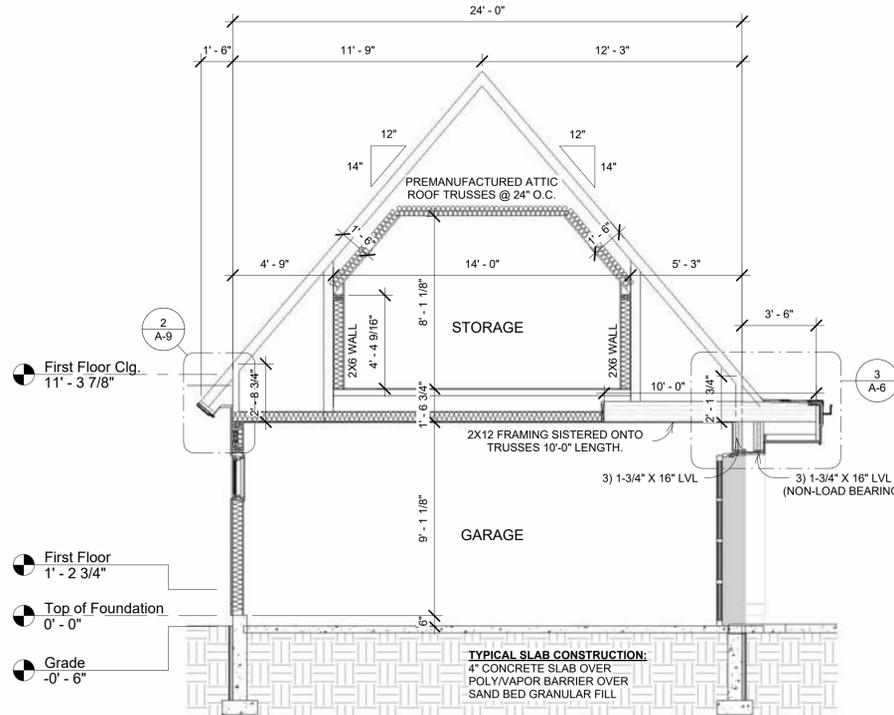

4 Cross Section - Garage III

1/4" = 1'-0"

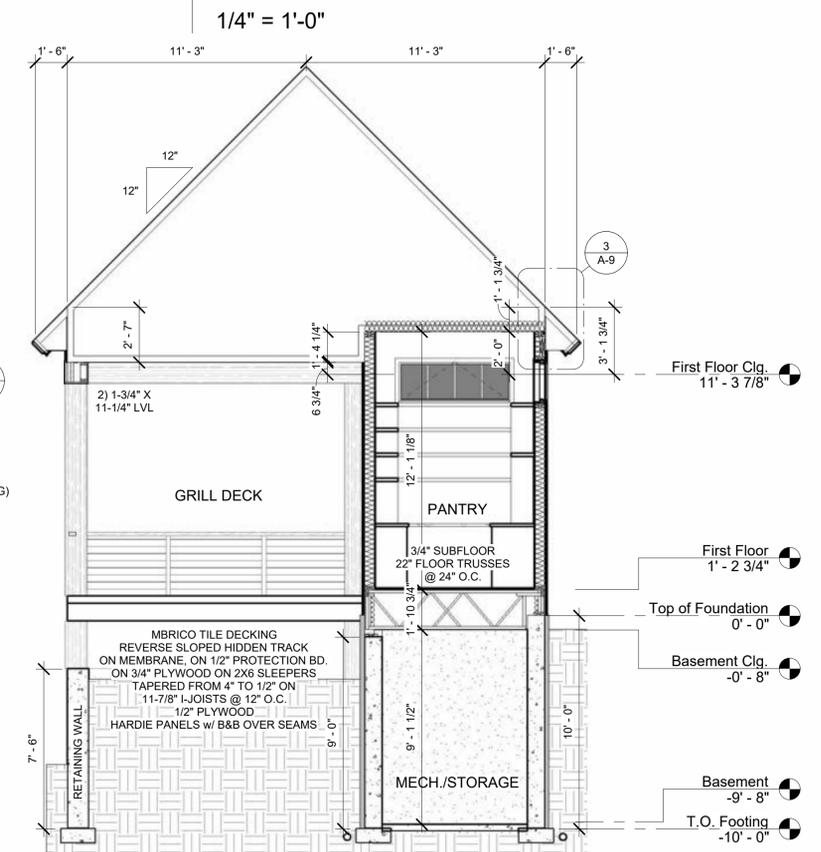

5 Cross Section - Grill Deck / Pantry / Mech.


1/4" = 1'-0"

Revision Schedule	Date
#	Description


DATE DRAWN: 05/05/23	CUSTOMER: TBD	PLAN REVIEW: TBD	RELEASE: Approver	DRAWN BY: Author
----------------------	---------------	------------------	-------------------	------------------

**SHEET INDEX**


- T-1 Title
- T-2/5 Exterior Perspectives
- A-1 Foundation Plan
- A-2 Lower Level Finish Plan
- A-3 Main Level Floor Plan
- A-4 Front Elevation
- A-5 Right Elevation
- A-6 Left Elevation
- A-7 Rear Elevation & Roof
- A-8/10 Building Sections
- A-11 Wall Sections
- I-1/3 Interior Elevations
- S-1/2 Framing Plan & Details
- E-1/2 Electrical Plans

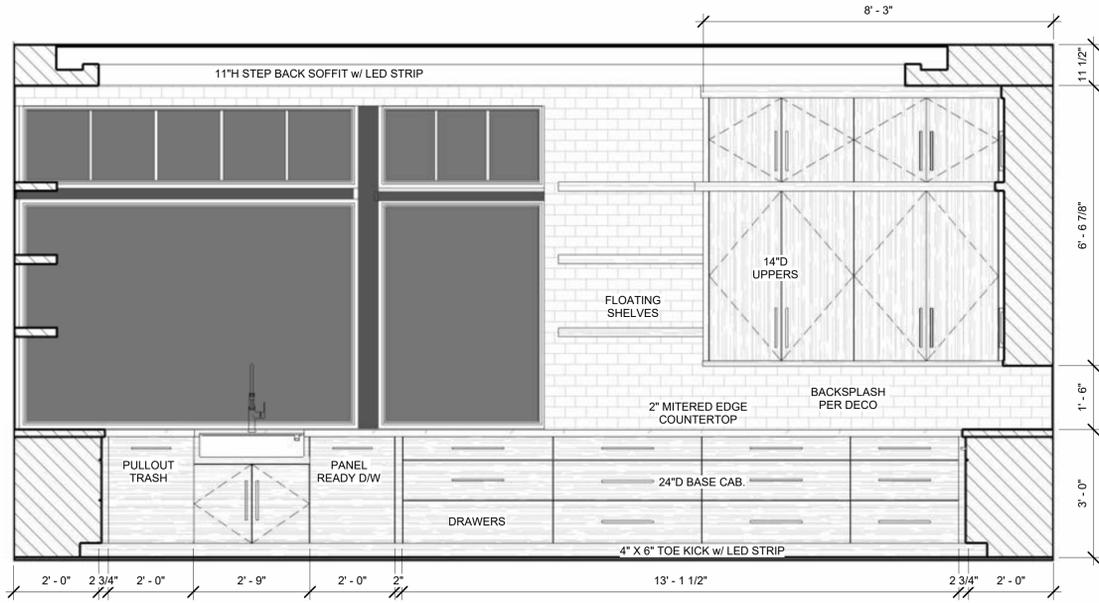


2 Kitchen I  
1/2" = 1'-0"

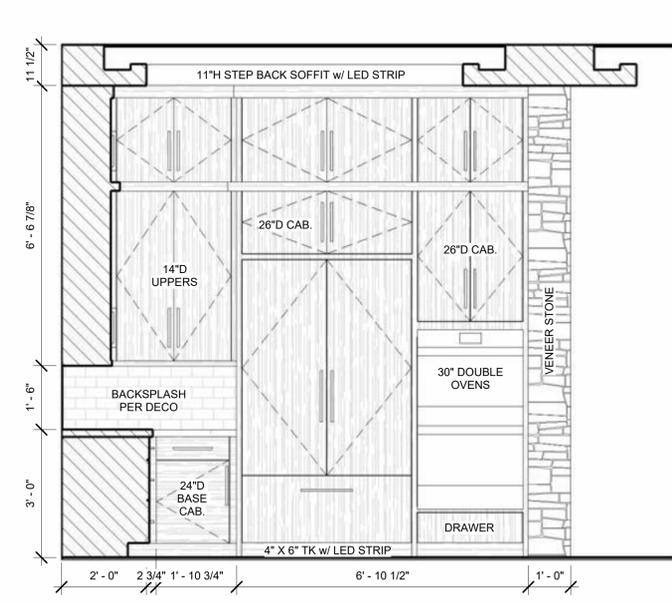


3 Kitchen II  
1/2" = 1'-0"

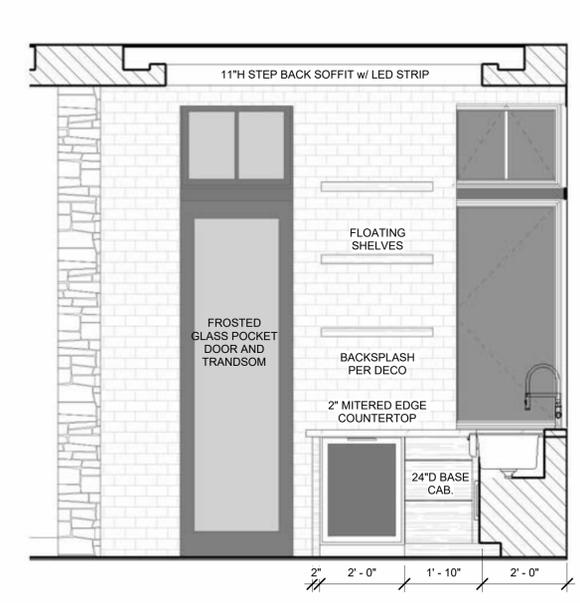


14 Kitchen III  
1/2" = 1'-0"

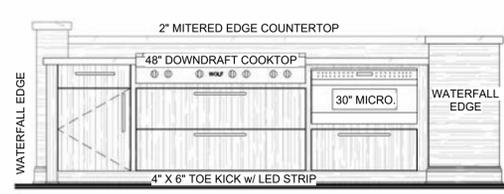


4 Kitchen Island I  
1/2" = 1'-0"

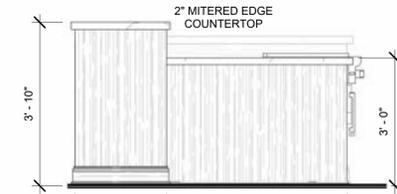


5 Kitchen Island II  
1/2" = 1'-0"

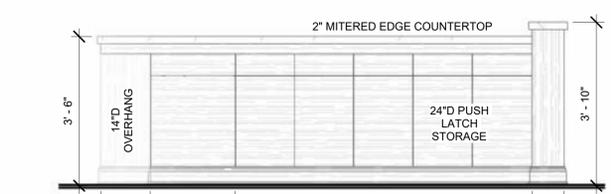


6 Kitchen Island III  
1/2" = 1'-0"

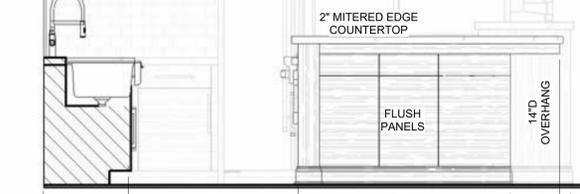


7 Kitchen Island IV  
1/2" = 1'-0"

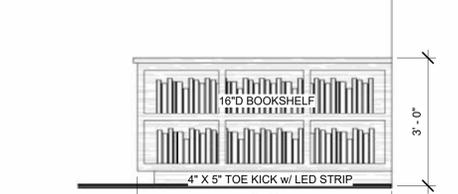


8 Dining Bookshelf  
1/2" = 1'-0"

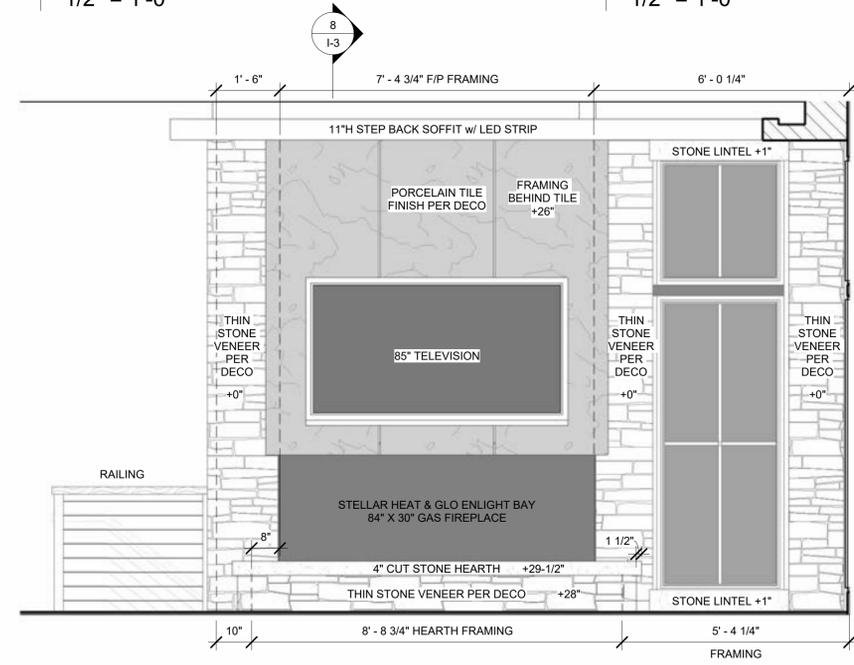


1 Great Room Fireplace  
1/2" = 1'-0"

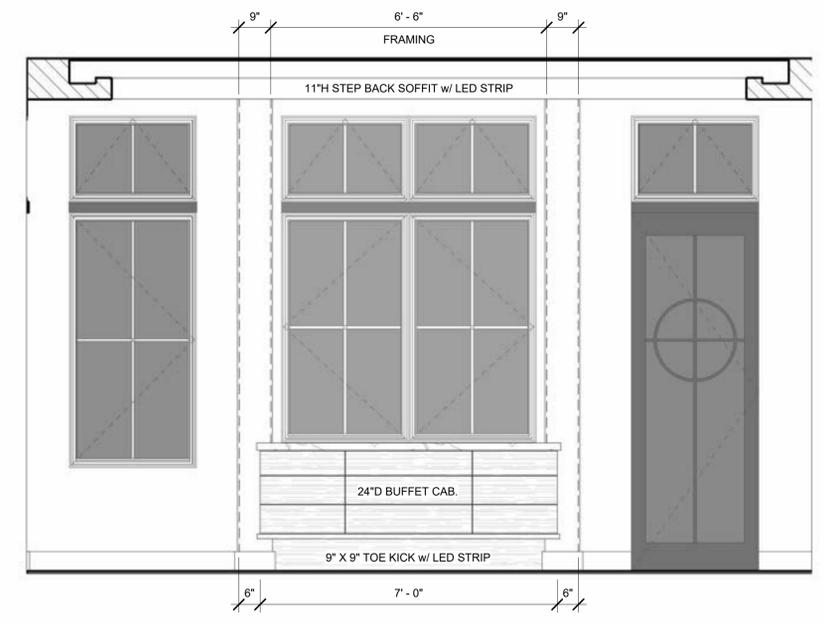

9 Dining Buffet  
1/2" = 1'-0"

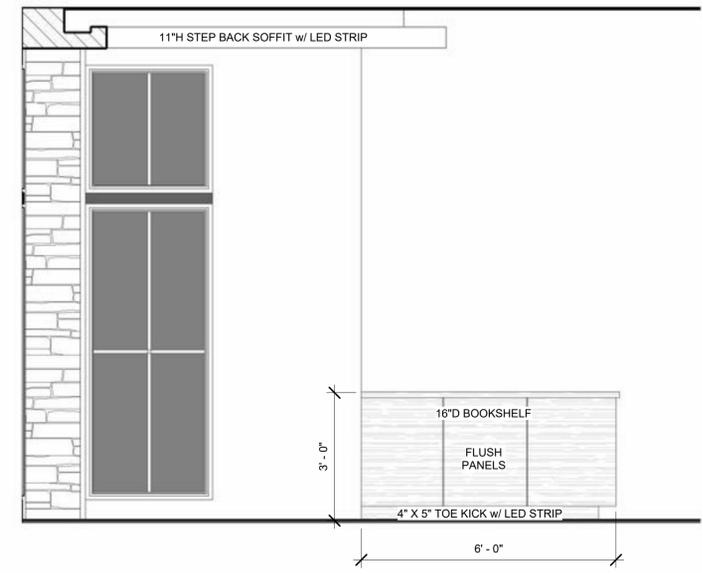

13 Dining Bookshelf II  
1/2" = 1'-0"

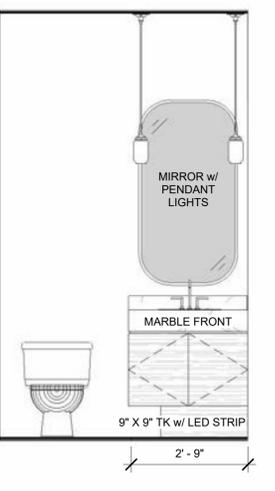


12 Powder Bath  
1/2" = 1'-0"

Revision #	Schedule	Description	Date
8	1-3		


DATE DRAWN: 11/05/21	CUSTOMER: TBD	PLAN REVIEW: TBD	RELEASE: Approver	DRAWN BY: Author
----------------------	---------------	------------------	-------------------	------------------

**SHEET INDEX**


- T-1 Title
- T-2/5 Exterior Perspectives
- A-1 Foundation Plan
- A-2 Lower Level Finish Plan
- A-3 Main Level Floor Plan
- A-4 Front Elevation
- A-5 Right Elevation
- A-6 Left Elevation
- A-7 Rear Elevation & Roof
- A-8/10 Building Sections
- A-11 Wall Sections
- I-1/3 Interior Elevations
- S-1/2 Framing Plan & Details
- E-1/2 Electrical Plans

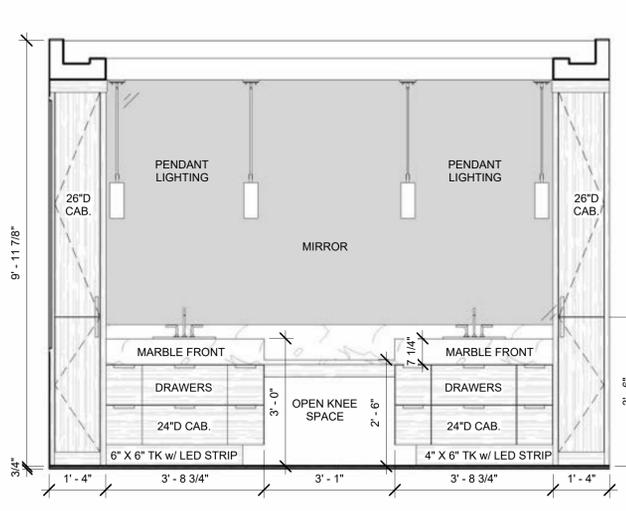


1 Owner's Bath  
1/2" = 1'-0"

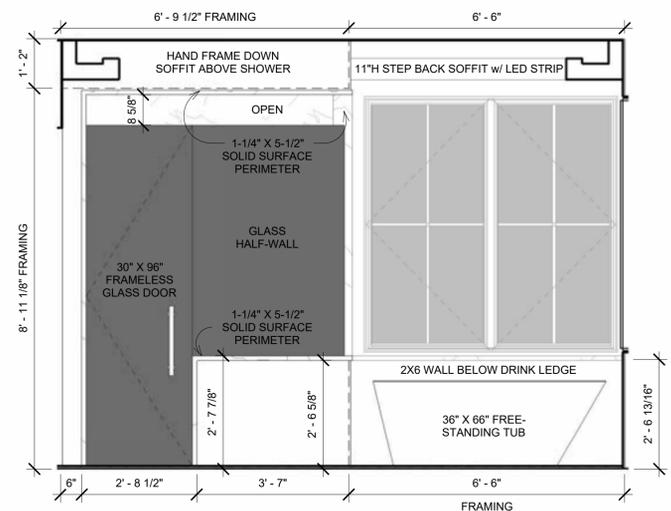


2 Owner's Bath II  
1/2" = 1'-0"

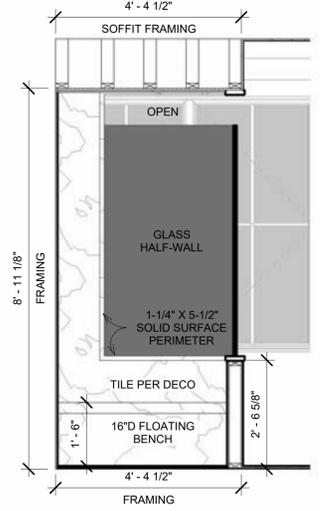


3 Owner's Bath III  
1/2" = 1'-0"

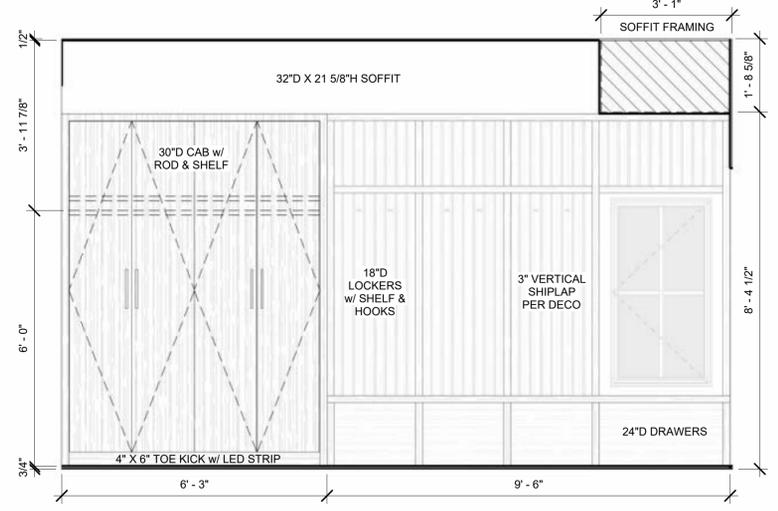


4 Mudroom I  
1/2" = 1'-0"

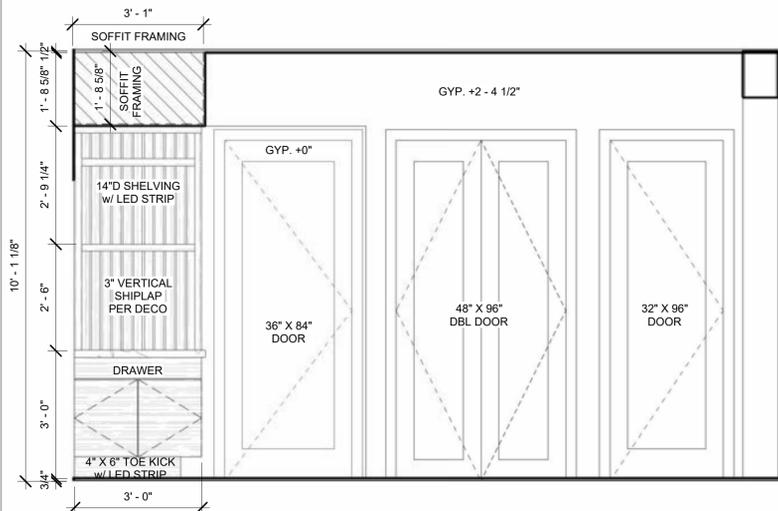


5 Mudroom II  
1/2" = 1'-0"

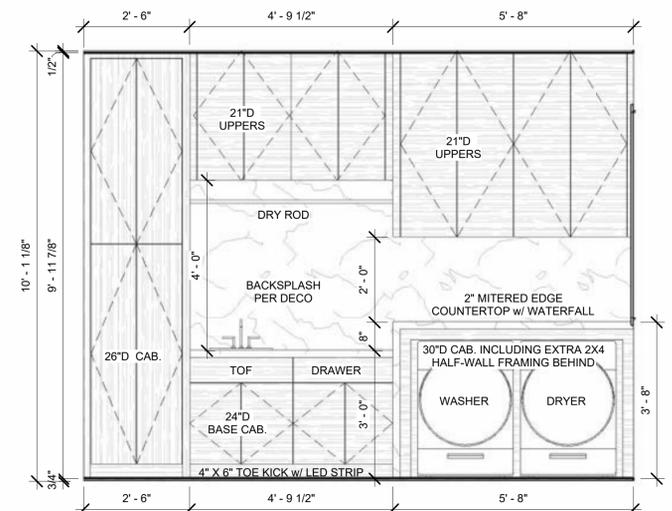


6 Laundry  
1/2" = 1'-0"

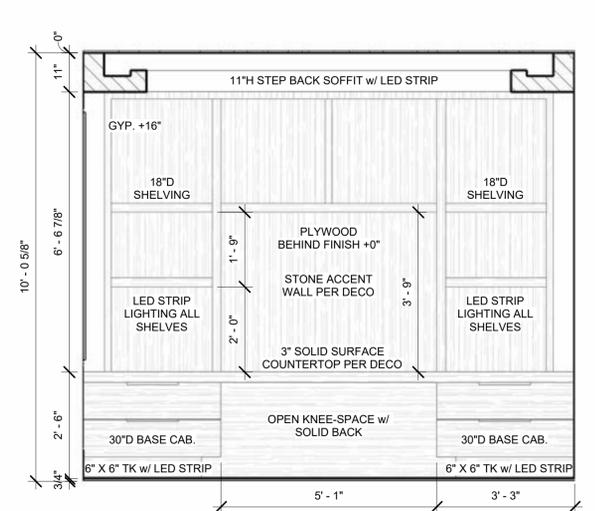


7 Office  
1/2" = 1'-0"

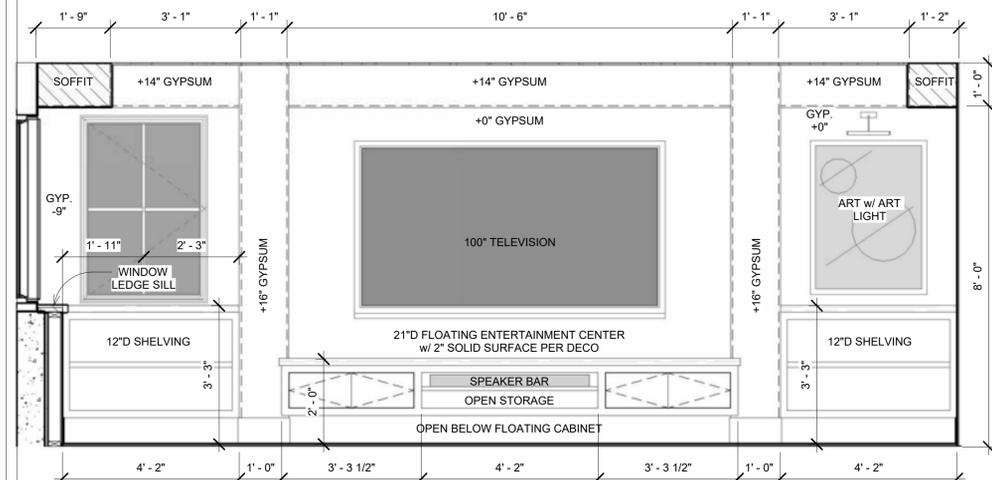


8 Family Room  
1/2" = 1'-0"

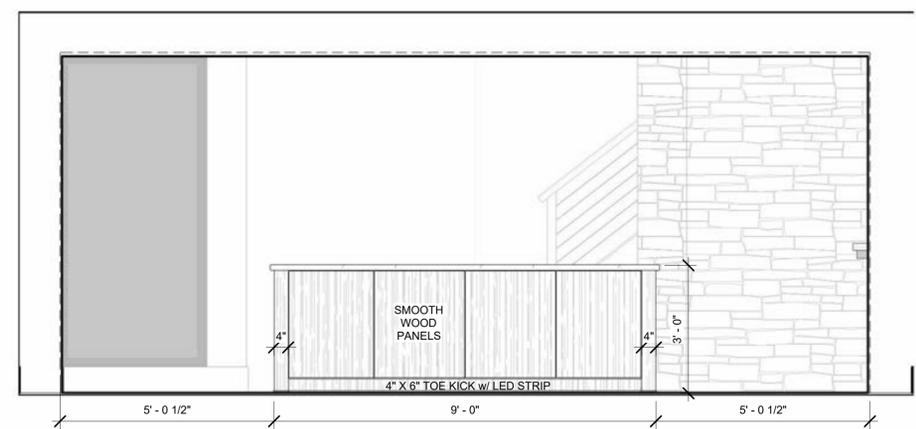

9 Family Room Seating I  
1/2" = 1'-0"

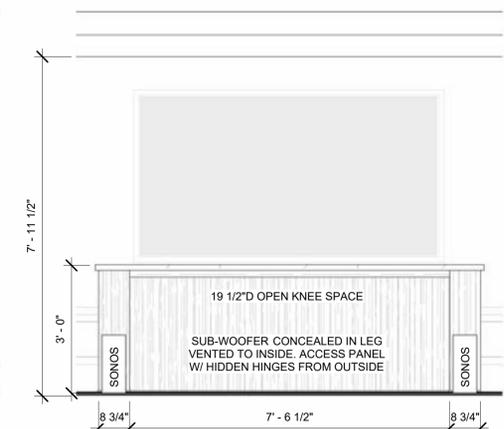

10 Family Room Seating III  
1/2" = 1'-0"

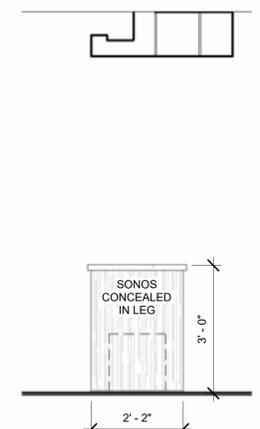

11 Family Room Seating II  
1/2" = 1'-0"

**CHARLES CUDDOO.**  
ARCHITECTURAL DESIGN • BUILD  
15050 23rd Ave. N. • Plymouth, MN 55447 • 612-333-8020 Phone  
charlescuddoo.com

© Charles Cuddoo Co.  
THESE PLANS AND THE WORK CONSTRUCTED PURSUANT TO THESE PLANS ARE THE SOLE AND EXCLUSIVE PROPERTY OF CHARLES CUDDOO ARCHITECTURAL DESIGN • BUILD. ANY REPRODUCTION OR USE OF THESE PLANS WITHOUT THE WRITTEN PERMISSION OF CHARLES CUDDOO ARCHITECTURAL DESIGN • BUILD IS STRICTLY PROHIBITED. COPYRIGHT © 2023

HEREBY CERTIFY THAT THIS PLAN WAS PREPARED BY ME OR UNDER MY CLOSE PERSONAL SUPERVISION AND I AM A DULY LICENSED ARCHITECT UNDER THE LAWS OF THE STATE OF MINNESOTA.  
DATE: \_\_\_\_\_  
SIGN: \_\_\_\_\_  
REG. NO: \_\_\_\_\_

RESIDENCE FOR: Pleasant View Model  
935 Pleasant View Rd, Chamnassen  
ADDRESS: MN 55317  
LOT No.: 01 BLOCK No.: 01  
PROJECT: Custom Home  
JOB No.: 1050101


Revision Schedule	
#	Description / Date

DATE DRAWN: 04/13/21  
CUSTOMER: TBD  
PLAN REVIEW: TBD  
RELEASE: Approver  
DRAWN BY: Author

**SHEET INDEX**


- T-1 Title
- T-2/5 Exterior Perspectives
- A-1 Foundation Plan
- A-2 Lower Level Finish Plan
- A-3 Main Level Floor Plan
- A-4 Front Elevation
- A-5 Right Elevation
- A-6 Left Elevation
- A-7 Rear Elevation & Roof
- A-8/10 Building Sections
- A-11 Wall Sections
- I-1/3 Interior Elevations
- S-1/2 Framing Plan & Details
- E-1/2 Electrical Plans

**I-2**  
Interior Elevations

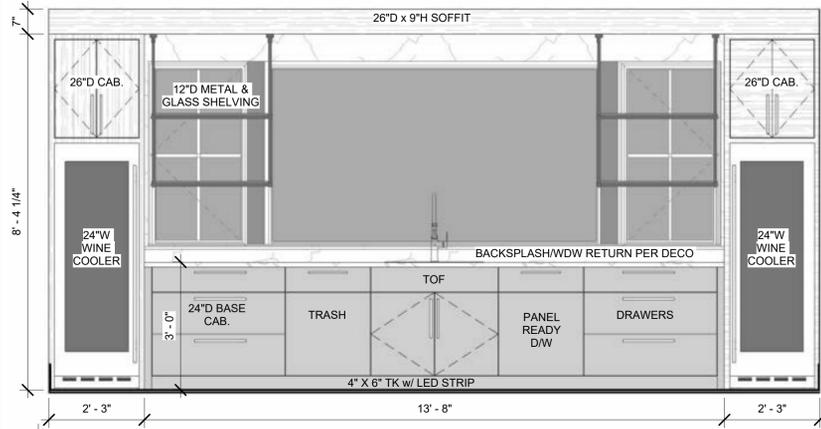


1 Wet Bar

1/2" = 1'-0"

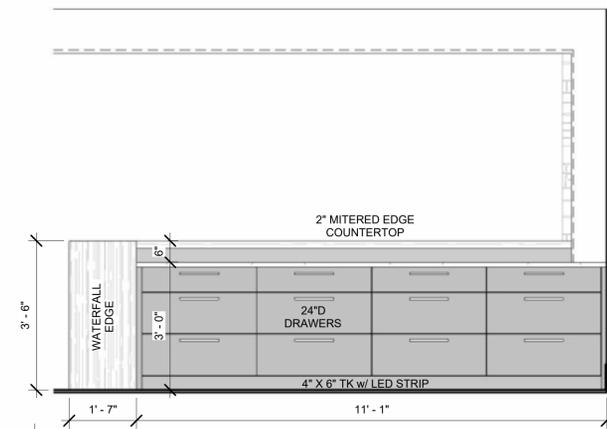


2 Wet Bar Island I

1/2" = 1'-0"

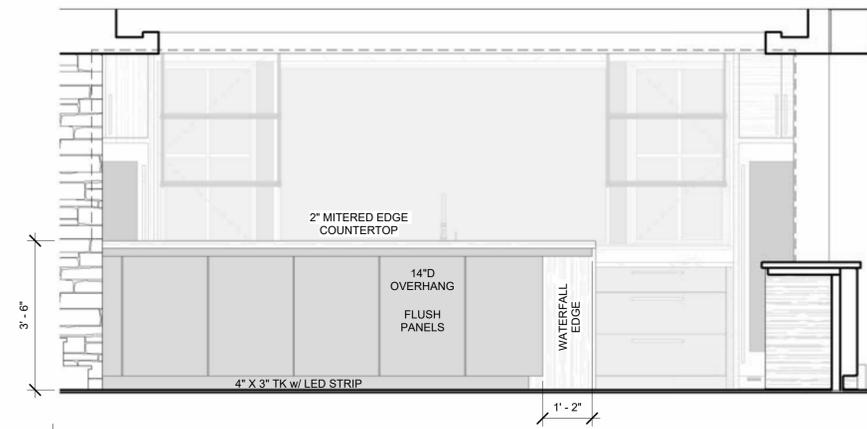


3 Wet Bar Island II

1/2" = 1'-0"

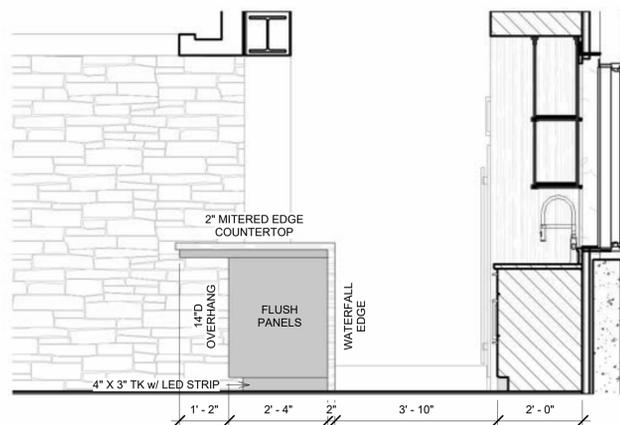


4 Wet Bar Island III

1/2" = 1'-0"

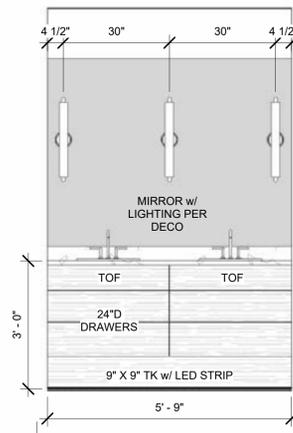


5 Bath #2 I

1/2" = 1'-0"

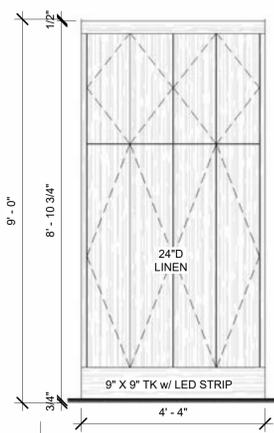


6 Bath #2 II

1/2" = 1'-0"

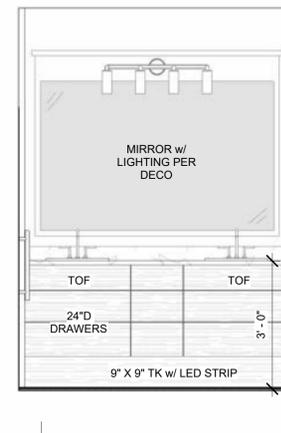

7 Bath #3

1/2" = 1'-0"

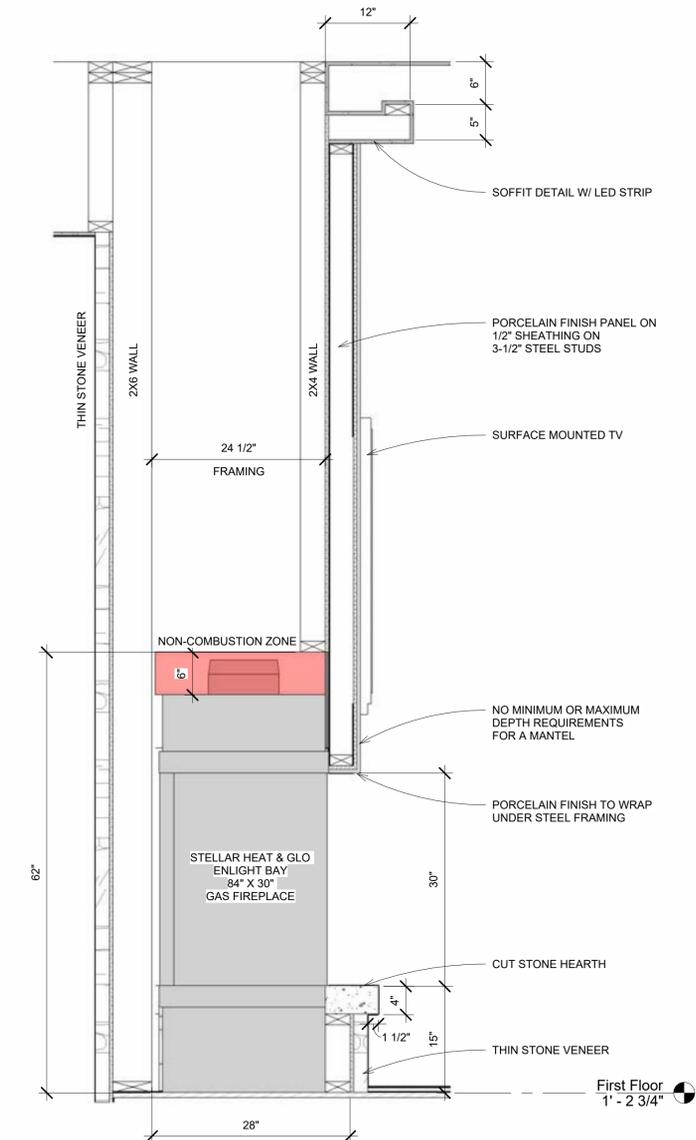

8 Detail - Fireplace Section

1" = 1'-0"

Revision #	Schedule	Description	Date

DATE DRAWN: 05/05/23	CUSTOMER: TBD	PLAN REVIEW: TBD	RELEASE: Approver	DRAWN BY: Author
----------------------	---------------	------------------	-------------------	------------------

**SHEET INDEX**

T-1	Title
T-2/5	Exterior Perspectives
A-1	Foundation Plan
A-2	Lower Level Finish Plan
A-3	Main Level Floor Plan
A-4	Front Elevation
A-5	Right Elevation
A-6	Left Elevation
A-7	Rear Elevation & Roof
A-8/10	Building Sections
A-11	Wall Sections
I-1/3	Interior Elevations
S-1/2	Framing Plan & Details
E-1/2	Electrical Plans



**CHARLES CUDDO CO.**  
ARCHITECTURAL DESIGN • BUILD

15000 23rd Ave. N. • Plymouth, MN 55447 • 612-333-8020 Phone  
charlescuddo.com

© Charles Cuddo Co.

THESE PLANS AND THE WORK CONSTRUCTED PURSUANT TO THESE PLANS ARE THE SOLE PROPERTY OF CHARLES CUDDO CO. NO PART OF THESE PLANS OR THE WORK CONSTRUCTED PURSUANT TO THESE PLANS IS TO BE REPRODUCED OR TRANSMITTED IN ANY FORM OR BY ANY MEANS, ELECTRONIC OR MECHANICAL, INCLUDING PHOTOCOPYING, RECORDING, OR BY ANY INFORMATION STORAGE AND RETRIEVAL SYSTEM, WITHOUT THE WRITTEN PERMISSION OF CHARLES CUDDO CO.

I HEREBY CERTIFY THAT THESE PLANS WERE PREPARED BY ME OR UNDER MY CLOSE PERSONAL SUPERVISION AND THAT I AM A LICENSED ARCHITECT UNDER THE LAWS OF THE STATE OF MINNESOTA

DATE \_\_\_\_\_  
SIGN \_\_\_\_\_  
REG. NO. \_\_\_\_\_

RESIDENCE FOR: Pleasant View Model

935 Pleasant View Rd, Chamhassen  
MN 55317  
ADDRESS: 935 Pleasant View Rd, Chamhassen  
LOT No.: Checklock No.: Designer  
PROJECT: Custom Home  
JOB No.: 1050101

Revision Schedule

#	Description	Date



DATE DRAWN: 10/02/25

CUSTOMER: TBD  
PLAN REVIEW: TBD  
RELEASE: Approver  
DRAWN BY: Author

SHEET INDEX

T-1	Title
T-2/5	Exterior Perspectives
A-1	Foundation Plan
A-2	Lower Level Finish Plan
A-3	Main Level Floor Plan
A-4	Front Elevation
A-5	Right Elevation
A-6	Left Elevation
A-7	Rear Elevation & Roof
A-8/10	Building Sections
A-11	Wall Sections
I-1/3	Interior Elevations
S-1/2	Framing Plan & Details
E-1/2	Electrical Plans

**I-4**  
Interior Perspectives

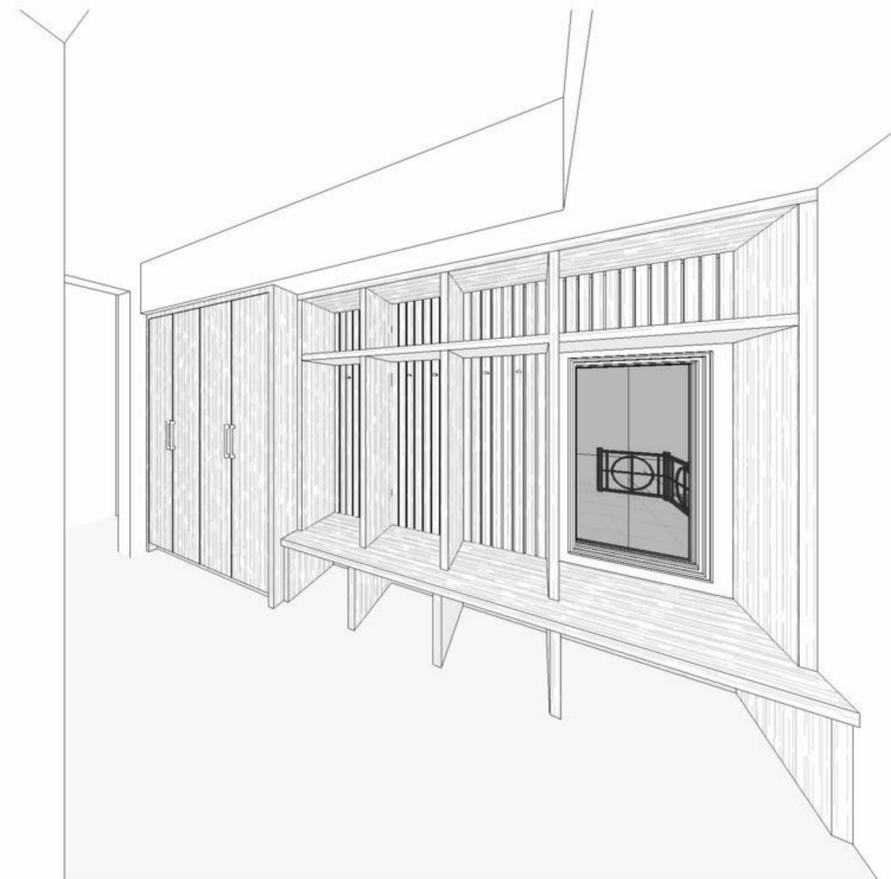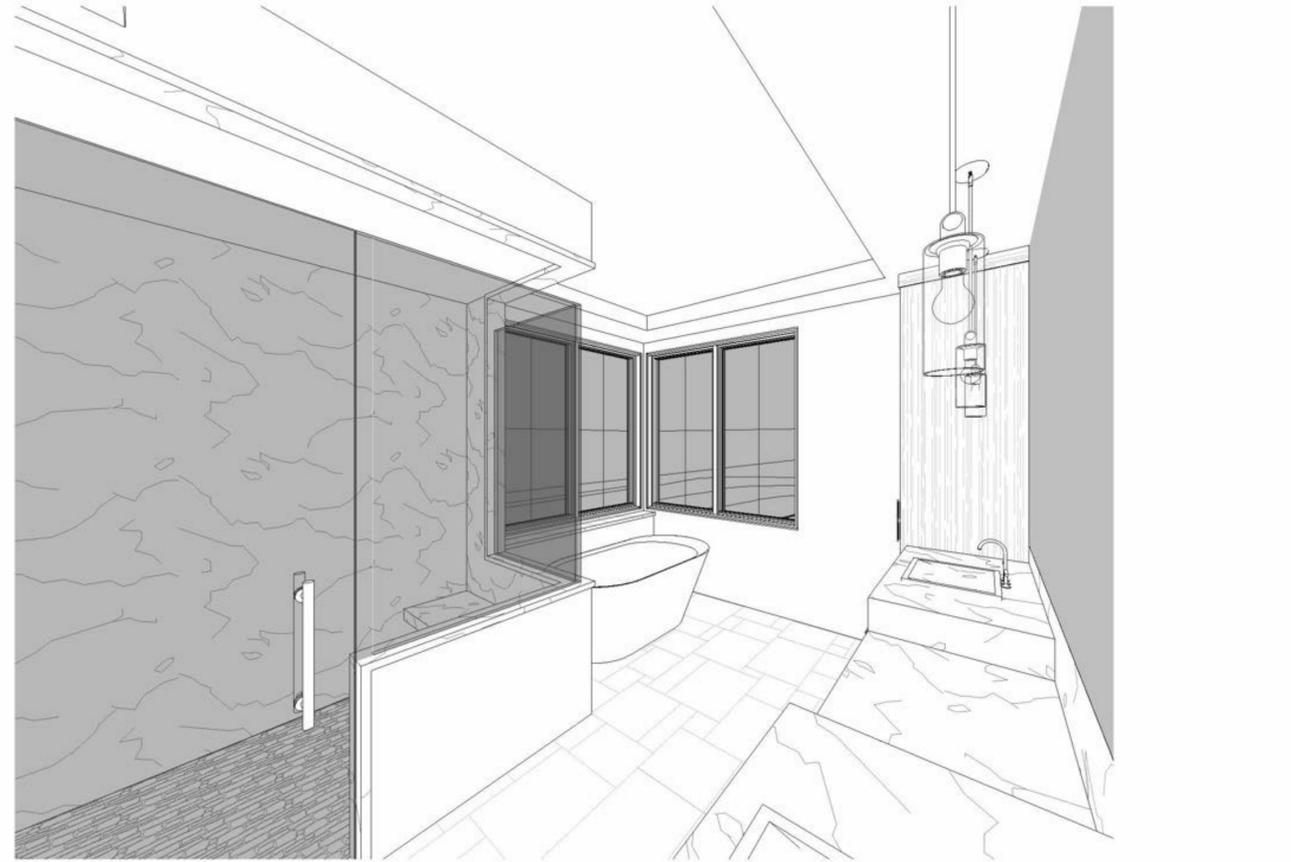

**CHARLES CUDDO CO.**  
 ARCHITECTURAL DESIGN • BUILD  
 15000 23rd Ave. N. • Plymouth, MN 55447 • 612-333-8020 Phone  
 charlescuddo.com

© Charles Cuddo Co.  
 THESE PLANS AND THE WORK CONSTRUCTED PURSUANT TO THEM ARE THE SOLE PROPERTY OF CHARLES CUDDO CO. ANY REPRODUCTION OR DISTRIBUTION OF THESE PLANS WITHOUT THE WRITTEN PERMISSION OF CHARLES CUDDO CO. IS STRICTLY PROHIBITED.  
 COPYRIGHT © 2023

I HEREBY CERTIFY THAT THIS PLAN WAS PREPARED BY ME OR UNDER MY CLOSE PERSONAL SUPERVISION AND THAT I AM A LICENSED ARCHITECT UNDER THE LAWS OF THE STATE OF MINNESOTA.  
 SIGN: \_\_\_\_\_ DATE: \_\_\_\_\_  
 REG. NO. \_\_\_\_\_

RESIDENCE FOR: **Pleasant View Model**  
 ADDRESS: 935 Pleasant View Rd, Chamhassen, MN 55317  
 LOT No.: Check#LOCK No.: Designer  
 PROJECT: Custom Home  
 JOB No.: 1050101


Revision Schedule		
#	Description	Date

DATE DRAWN: 10/02/25  
 CUSTOMER: TBD  
 PLAN REVIEW: \_\_\_\_\_  
 RELEASE: Approver  
 DRAWN BY: Author

**SHEET INDEX**

T-1	Title
T-2/5	Exterior Perspectives
A-1	Foundation Plan
A-2	Lower Level Finish Plan
A-3	Main Level Floor Plan
A-4	Front Elevation
A-5	Right Elevation
A-6	Left Elevation
A-7	Rear Elevation & Roof
A-8/10	Building Sections
A-11	Wall Sections
I-1/3	Interior Elevations
S-1/2	Framing Plan & Details
E-1/2	Electrical Plans

**I-5**  
 Interior Perspectives

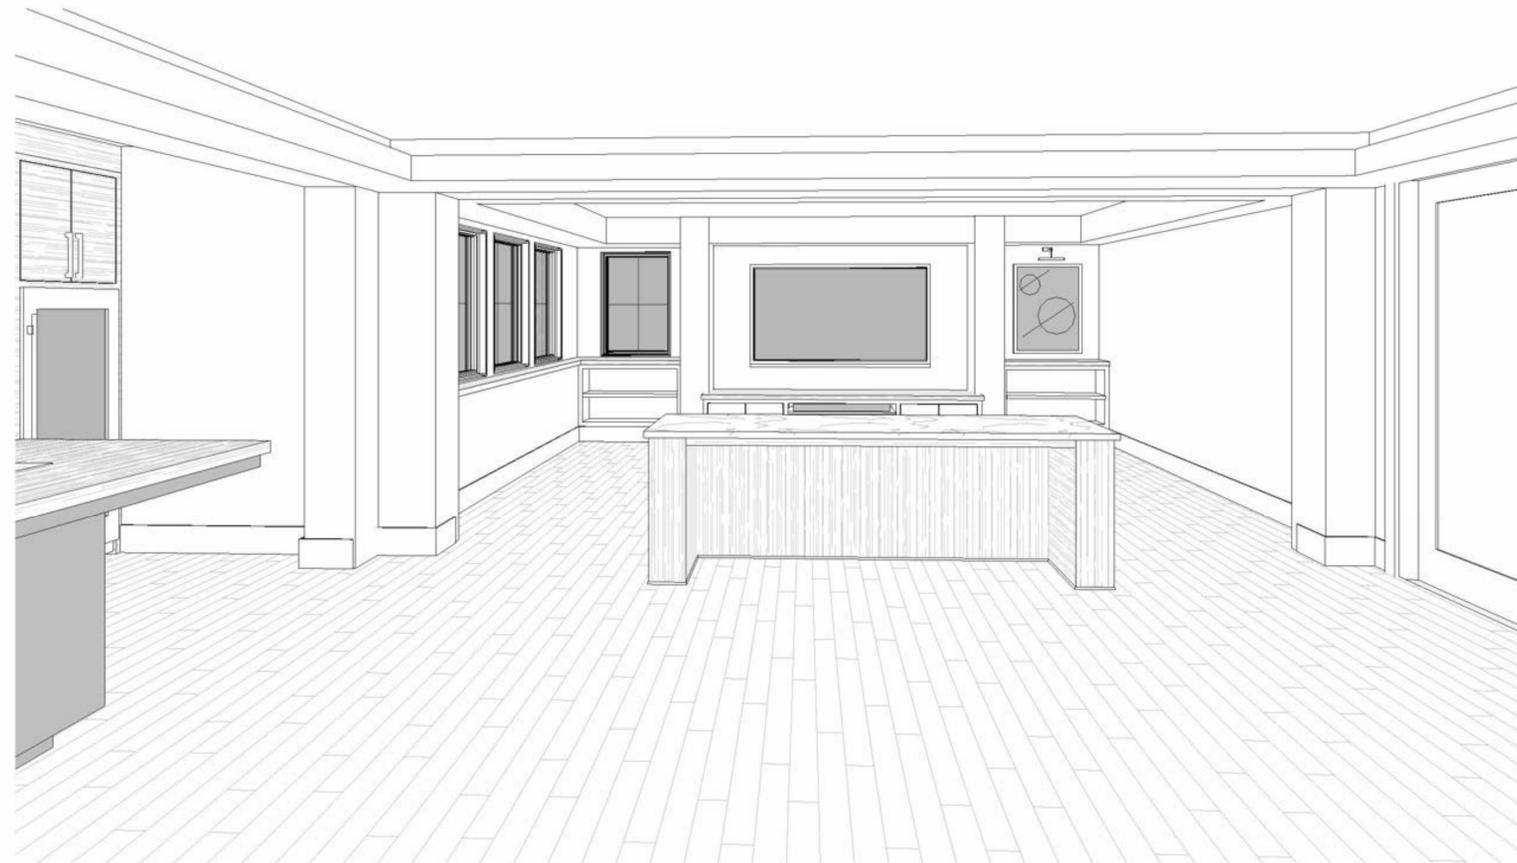

**CHARLES CUDDOO.**  
ARCHITECTURAL DESIGN • BUILD

15000 23rd Ave. N. • Plymouth, MN 55447 • 612-333-8020 Phone  
charlescuddoo.com

© Charles Cudd Co.

THESE PLANS AND THE WORK CONSTRUCTED PURSUANT TO THEM ARE THE SOLE PROPERTY OF CHARLES CUDDOO ARCHITECTURAL DESIGN & BUILD. NO PART OF THESE PLANS OR THE WORK CONSTRUCTED PURSUANT TO THEM MAY BE REPRODUCED OR TRANSMITTED IN ANY FORM OR BY ANY MEANS, ELECTRONIC OR MECHANICAL, INCLUDING PHOTOCOPYING, RECORDING, OR BY ANY INFORMATION STORAGE AND RETRIEVAL SYSTEM, WITHOUT THE WRITTEN PERMISSION OF CHARLES CUDDOO ARCHITECTURAL DESIGN & BUILD. COPYRIGHT © 2023

I HEREBY CERTIFY THAT THESE PLANS WERE PREPARED BY ME OR UNDER MY CLOSE PERSONAL SUPERVISION AND THAT I AM A LICENSED ARCHITECT UNDER THE LAWS OF THE STATE OF MINNESOTA.

DATE: \_\_\_\_\_  
SIGN: \_\_\_\_\_  
REG. NO: \_\_\_\_\_

RESIDENCE FOR: **Pleasant View Model**  
ADDRESS: 935 Pleasant View Rd, Chamnassen MN 55317  
LOT No.: \_\_\_\_\_ Check#/LOCK No.: \_\_\_\_\_ Designer  
PROJECT: Custom Home  
JOB No.: 1050101

Revision Schedule		
#	Description	Date

DATE DRAWN: 10/02/25  
CUSTOMER: TBD  
PLAN REVIEW: \_\_\_\_\_ Approver  
RELEASE: \_\_\_\_\_ Author  
DRAWN BY: \_\_\_\_\_

**SHEET INDEX**

T-1	Title
T-2/5	Exterior Perspectives
A-1	Foundation Plan
A-2	Lower Level Finish Plan
A-3	Main Level Floor Plan
A-4	Front Elevation
A-5	Right Elevation
A-6	Left Elevation
A-7	Rear Elevation & Roof
A-8/10	Building Sections
A-11	Wall Sections
I-1/3	Interior Elevations
S-1/2	Framing Plan & Details
E-1/2	Electrical Plans

**I-6**  
Interior Perspectives

ELECTRICAL SYMBOL LEGEND		
	WALL MOUNTED SCENCE	
	WALL MOUNTED SCENCE-WEATHERPROOF	
	EXTERIOR SINGLE FLOOD LIGHT	
	EXTERIOR LANTERN WEATHERPROOF	
	PENDANT LIGHT/CHANDELIER	
	VANITY LIGHT	
	DISK LIGHT	
	PUCK LIGHT	
	FIXTURE LIGHT	
	DIRECTIONAL ACCENT LIGHTING	
	TREAD LIGHT (PHOTO-CELL)	CEILING FAN
	DIRECTIONAL EXTERIOR TREAD LIGHTING-WEATHERPROOF	CEILING FAN/LIGHT COMBO
	ART LIGHT	
	WALL OUTLET	WALL SWITCH-ONE WAY
	WALL OUTLET-WEATHERPROOF	WALL SWITCH-TWO WAY
	FLOOR OUTLET	WALL SWITCH-THREE WAY
	CEILING OUTLET	



1 Lower Level Recessed Can Layout  
 1/4" = 1'-0"

**CHARLES CUDDOO.**  
 ARCHITECTURAL DESIGN • BUILD  
 15000 23rd Ave. N. • Plymouth, MN 55447 • 612-333-8020 Phone  
 charlescuddoo.com

© Charles Cudd Co.  
 THESE PLANS AND THE WORK CONSTRUCTED PURSUANT TO THEM ARE THE SOLE PROPERTY OF CHARLES CUDDOO ARCHITECTURAL DESIGN • BUILD. NO PART OF THESE PLANS OR THE WORK HEREON MAY BE REPRODUCED OR TRANSMITTED IN ANY FORM OR BY ANY MEANS, ELECTRONIC OR MECHANICAL, WITHOUT PERMISSION IN WRITING FROM CHARLES CUDDOO ARCHITECTURAL DESIGN • BUILD. COPYRIGHT © 2023

I HEREBY CERTIFY THAT THIS PLAN WAS PREPARED BY ME OR UNDER MY CLOSE PERSONAL SUPERVISION AND THAT I AM A LICENSED PROFESSIONAL ARCHITECT UNDER THE LAWS OF THE STATE OF MINNESOTA  
 SIGN: \_\_\_\_\_ DATE: \_\_\_\_\_  
 REG. NO: \_\_\_\_\_

RESIDENCE FOR: **Pleasant View Model**  
 ADDRESS: 935 Pleasant View Rd, Chamnassen MN 55317  
 LOT No.: 01 BLOCK No.: 01  
 PROJECT: Custom Home  
 JOB No.: 1050101

Revision Schedule		
#	Description	Date

DATE DRAWN: 05/04/23  
 CUSTOMER: TBD  
 PLAN REVIEW: TBD  
 RELEASE: Approver  
 DRAWN BY: Author

SHEET INDEX	
T-1	Title
T-2/5	Exterior Perspectives
A-1	Foundation Plan
A-2	Lower Level Finish Plan
A-3	Main Level Floor Plan
A-4	Front Elevation
A-5	Right Elevation
A-6	Left Elevation
A-7	Rear Elevation & Roof
A-8/10	Building Sections
A-11	Wall Sections
I-1/3	Interior Elevations
S-1/2	Framing Plan & Details
E-1/2	Electrical Plans

**E-1**  
 Electrical Plan Lower Level

ELECTRICAL SYMBOL LEGEND	
	WALL MOUNTED SCENCE
	WALL MOUNTED SCENCE-WEATHERPROOF
	EXTERIOR SINGLE FLOOD LIGHT
	EXTERIOR LANTERN-WEATHERPROOF
	PENDANT LIGHT/HANDLIER
	VANITY LIGHT
	DISK LIGHT
	PUCK LIGHT
	FIXTURE LIGHT
	DIRECTIONAL ACCENT LIGHTING
	TREAD LIGHT (PHOTO-CELL)
	DIRECTIONAL EXTERIOR TREAD LIGHTING-WEATHERPROOF
	ART LIGHT
	WALL OUTLET
	WALL OUTLET-WEATHERPROOF
	FLOOR OUTLET
	CEILING OUTLET
	CEILING FAN
	CEILING FAN/LIGHT COMBO
	WALL SWITCH-ONE WAY
	WALL SWITCH-TWO WAY
	WALL SWITCH-THREE WAY
	LED LIGHTING



1 Main Level Recessed Can Layout  
1/4" = 1'-0"

**CHARLES CUDDO**  
ARCHITECTURAL DESIGN • BUILD  
15000 23rd Ave. N. • Plymouth, MN 55447 • 612-333-8020 Phone  
charlescuddo.com

© Charles Cuddo Co.  
THESE PLANS AND THE WORK CONSTRUCTED PURSUANT TO THEM ARE THE SOLE PROPERTY OF CHARLES CUDDO ARCHITECTURAL DESIGN • BUILD. ANY REPRODUCTION OR USE OF THESE PLANS WITHOUT THE WRITTEN PERMISSION OF CHARLES CUDDO ARCHITECTURAL DESIGN • BUILD IS STRICTLY PROHIBITED. COPYRIGHT © 2023

I HEREBY CERTIFY THAT THIS PLAN WAS PREPARED BY ME OR UNDER MY CLOSE PERSONAL SUPERVISION AND THAT I AM A LICENSED ARCHITECT REGISTERED UNDER THE LAWS OF THE STATE OF MINNESOTA.  
DATE: \_\_\_\_\_  
SIGN: \_\_\_\_\_  
REG. NO: \_\_\_\_\_


RESIDENCE FOR: **Pleasant View Model**  
935 Pleasant View Rd, Chamhassen  
MN 55317  
LOT No.: 01 BLOCK No.: 01  
PROJECT: Custom Home  
JOB No.: 1050101

Revision Schedule	
#	Date

DATE DRAWN: 05/04/23  
CUSTOMER: TBD  
PLAN REVIEW: TBD  
RELEASE: Approver  
DRAWN BY: Author


SHEET INDEX	
T-1	Title
T-2/5	Exterior Perspectives
A-1	Foundation Plan
A-2	Lower Level Finish Plan
A-3	Main Level Floor Plan
A-4	Front Elevation
A-5	Right Elevation
A-6	Left Elevation
A-7	Rear Elevation & Roof
A-8/10	Building Sections
A-11	Wall Sections
I-1/3	Interior Elevations
S-1/2	Framing Plan & Details
E-1/2	Electrical Plans

**E-2**  
Electrical Plan Main Level

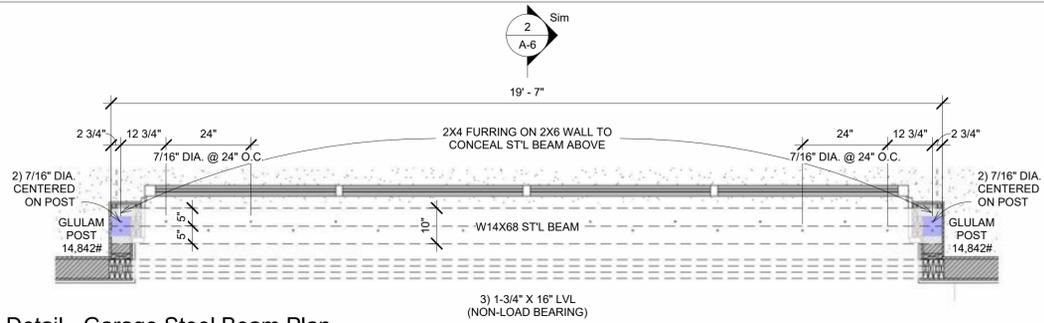


1 Detail - Garage Steel Beam Plan

1/2" = 1'-0"

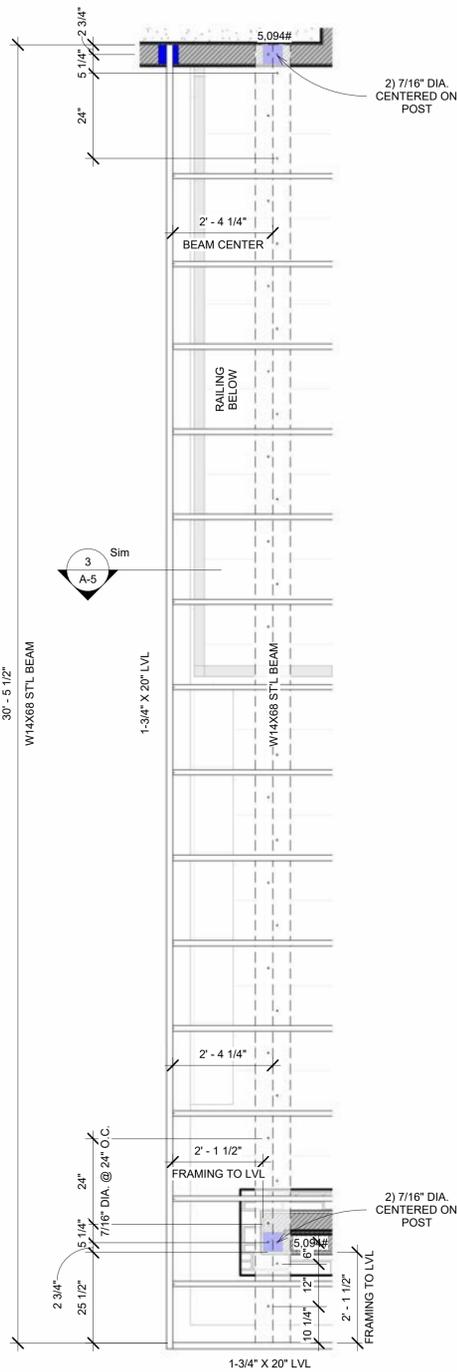

2 Detail - Front Porch Steel Beam Plan

1/2" = 1'-0"

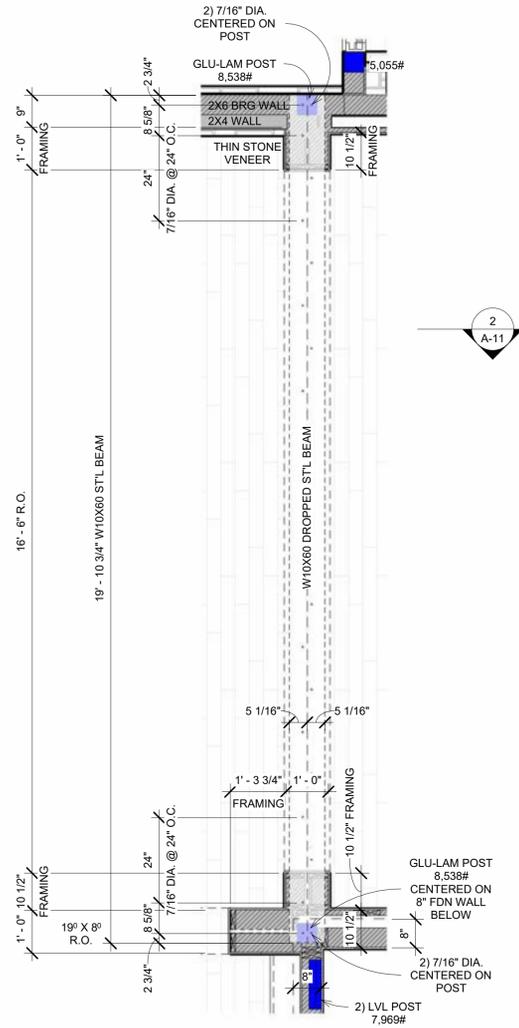

3 Detail - LL Wet Bar Steel Beam Plan

1/2" = 1'-0"


Revision Schedule		
#	Description	Date

DATE DRAWN: 05/05/23	CUSTOMER: TBD	PLAN REVIEW: TBD	RELEASE: Approver	DRAWN BY: Author
----------------------	---------------	------------------	-------------------	------------------

SHEET INDEX	
T-1	Title
T-2/5	Exterior Perspectives
A-1	Foundation Plan
A-2	Lower Level Finish Plan
A-3	Main Level Floor Plan
A-4	Front Elevation
A-5	Right Elevation
A-6	Left Elevation
A-7	Rear Elevation & Roof
A-8/10	Building Sections
A-11	Wall Sections
I-1/3	Interior Elevations
S-1/2	Framing Plan & Details
E-1/2	Electrical Plans



1 Lower Level Overall FFP  
3/16" = 1'-0"

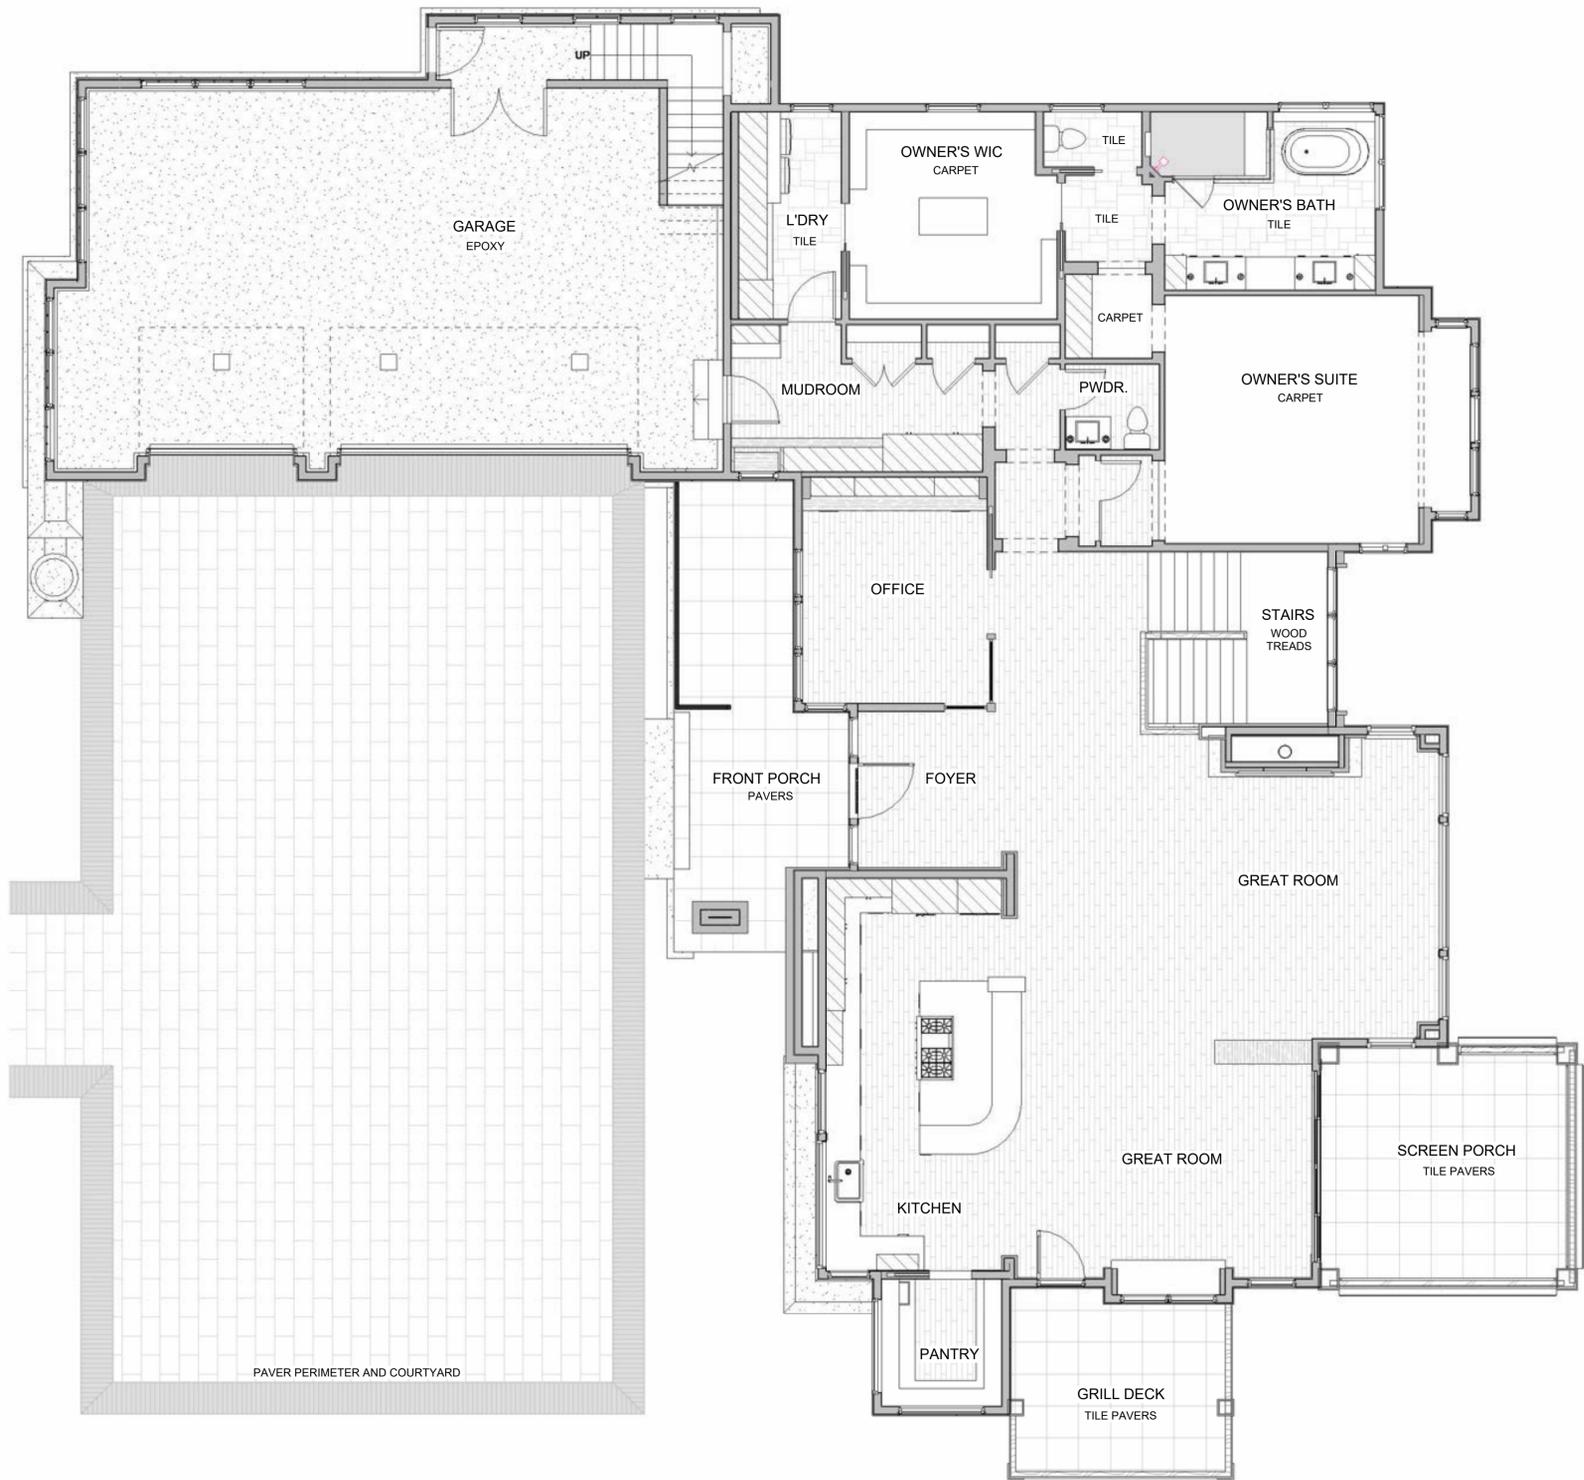

2 Main Level Structural FFP  
3/16" = 1'-0"

**CHARLES CUDDOO.**  
ARCHITECTURAL DESIGN • BUILD  
15000 23rd Ave. N. • Plymouth, MN 55447 • 612-333-8020 Phone  
charlescuddoo.com

© Charles Cuddoo Co.  
THESE PLANS AND THE WORK CONSTRUCTED PURSUANT TO THIS CONTRACT ARE SOLELY THE PROPERTY OF CHARLES CUDDOO ARCHITECTURAL DESIGN • BUILD. NO PART OF THIS DOCUMENT IS TO BE REPRODUCED OR TRANSMITTED IN ANY FORM OR BY ANY MEANS, ELECTRONIC OR MECHANICAL, WITHOUT PERMISSION IN WRITING FROM CHARLES CUDDOO ARCHITECTURAL DESIGN • BUILD.

I HEREBY CERTIFY THAT THIS PLAN WAS PREPARED BY ME OR UNDER MY CLOSE PERSONAL SUPERVISION AND THAT I AM A LICENSED ARCHITECT UNDER THE LAWS OF THE STATE OF MINNESOTA.  
DATE: \_\_\_\_\_  
SIGN: \_\_\_\_\_  
REG. NO: \_\_\_\_\_

RESIDENCE FOR: Pleasant View Model  
935 Pleasant View Rd, Chamhassen  
ADDRESS: MN 55317  
LOT No.: Check/LOCK No.: Designer  
PROJECT: Custom Home  
JOB No.: 1050101

Revision Schedule	
#	Description / Date

DATE DRAWN: 09/03/26  
CUSTOMER: TBD  
PLAN REVIEW: TBD  
RELEASE: Approver  
DRAWN BY: Author

**SHEET INDEX**

T-1	Title
T-2/5	Exterior Perspectives
A-1	Foundation Plan
A-2	Lower Level Finish Plan
A-3	Main Level Floor Plan
A-4	Front Elevation
A-5	Right Elevation
A-6	Left Elevation
A-7	Rear Elevation & Roof
A-8/10	Building Sections
A-11	Wall Sections
I-1/3	Interior Elevations
S-1/2	Framing Plan & Details
E-1/2	Electrical Plans

**W-1**  
Finished Floor Plans